
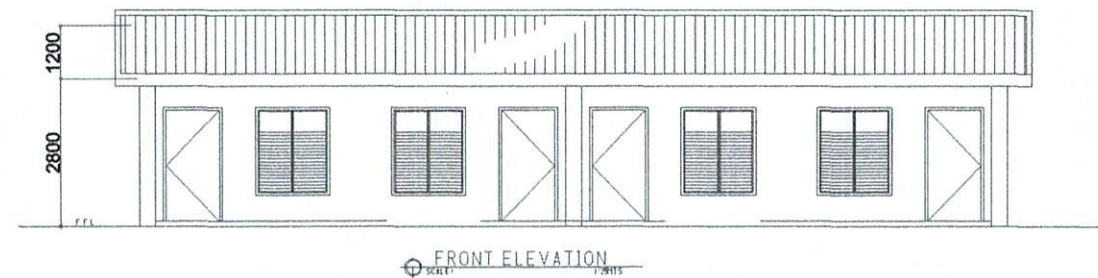



SSR- BLDG.

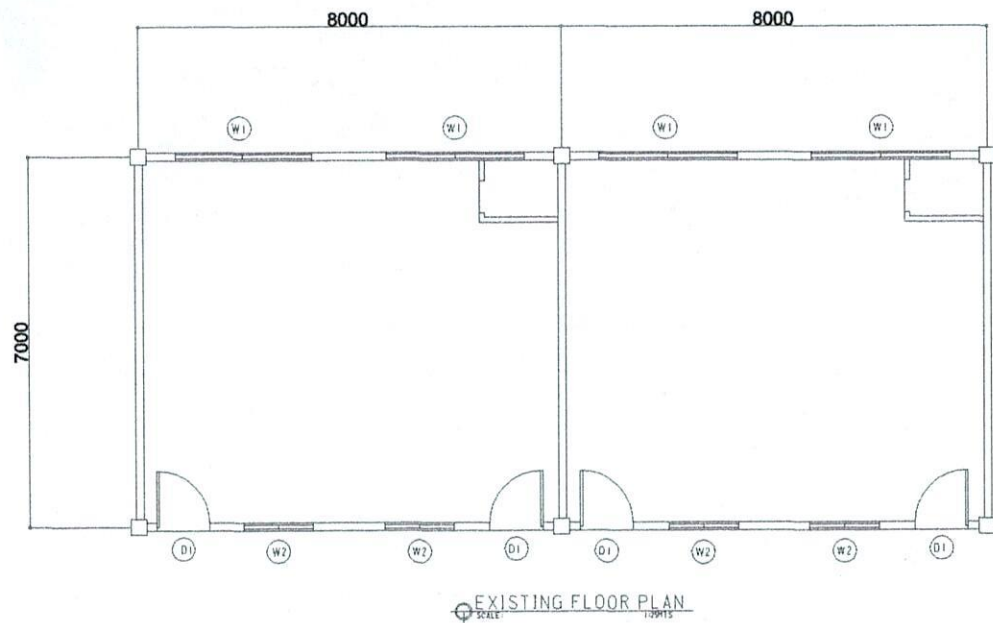


CITY ENGINEER'S
O F F I C E

PROJECT TITLE:	DRAWN BY:	RECOMMENDING APPROVAL :	APPROVED BY:
REPAIR/IMPROV. OF MULTI-PURPOSE HALL (TUGOS ELEMENTARY SCHOOL)			
LOC: BRGY. TUGOS, WEST DISTRICT SORSOGON CITY	MaPamelaLegaspi DRAFTING AIDE	ROEL D. DOMER, C.E./RMP CITY ENGINEER	MA. ESTER E. HAMOR CITY MAYOR


SSR- BLDG.

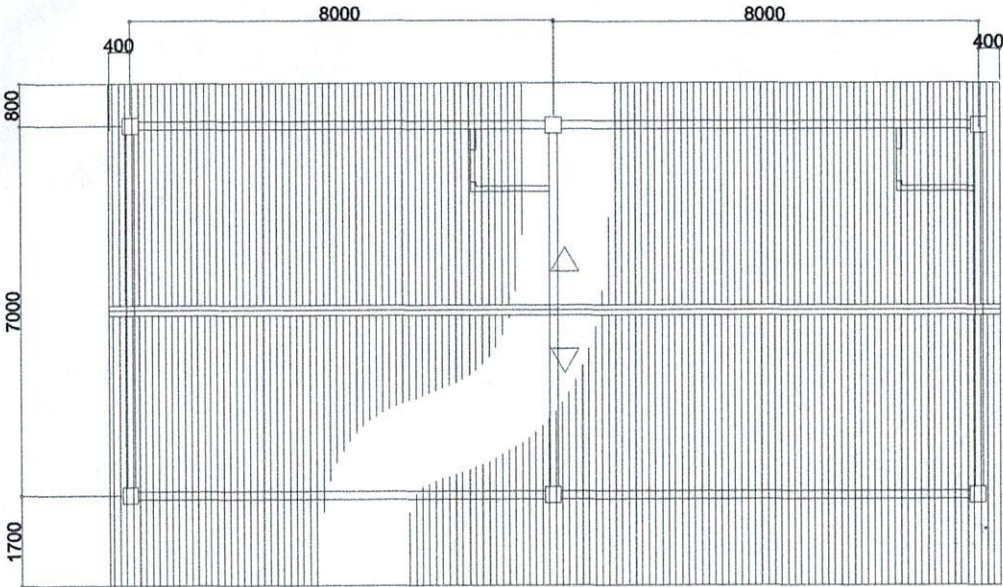


ROOF PLAN
SCALE: 1/8"=1'-0"

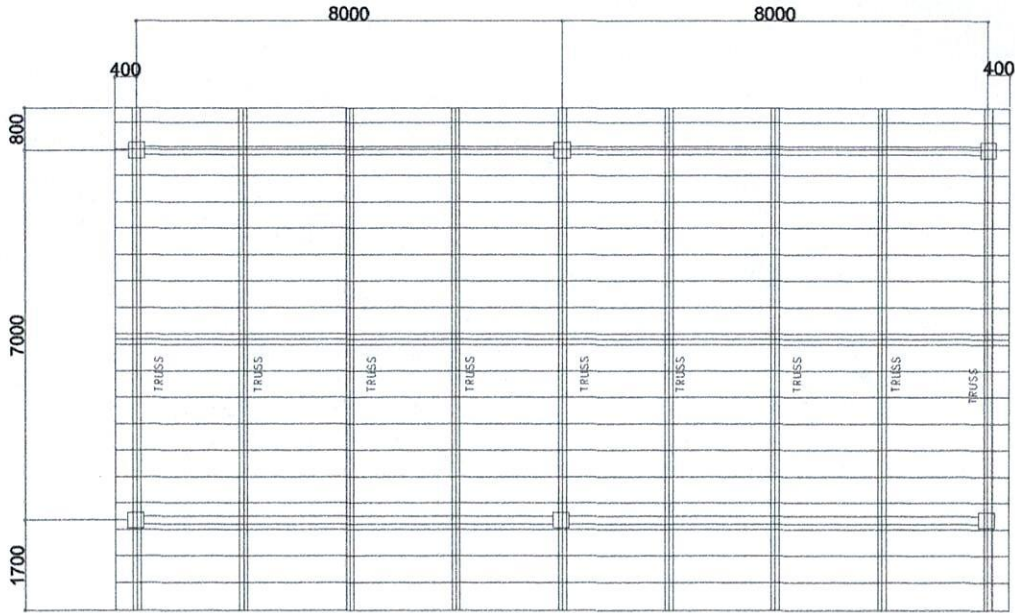

ROOF FRAMING PLAN
SCALE: 1/8"=1'-0"

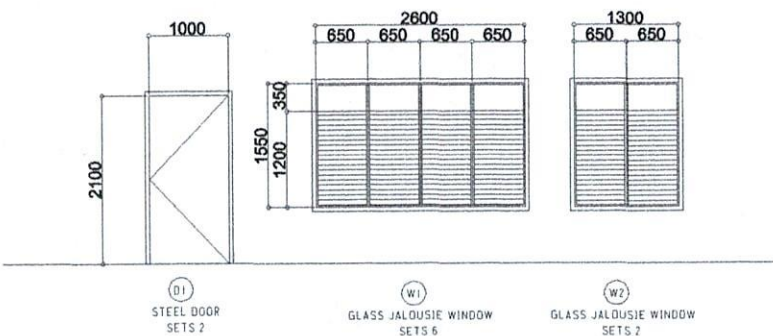

DOORS & WINDOWS SCHEDULE
SCALE: 1/8"=1'-0"


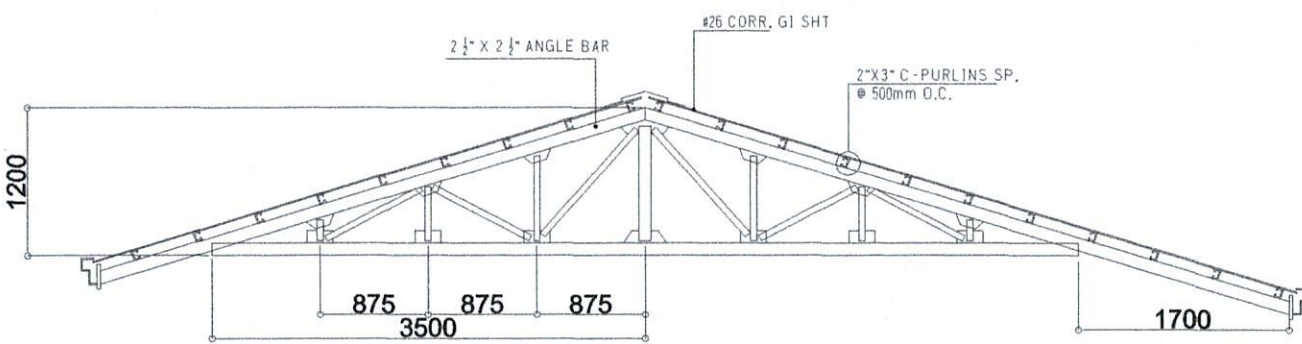


TRUSS DET.
SCALE: 1/8"=1'-0"



CITY ENGINEER'S
OFFICE

PROJECT TITLE:	DRAWN BY:	RECOMMENDING APPROVAL:	APPROVED BY:
REPAIR/IMPROV. OF MULTI-PURPOSE HALL (TUGOS ELEMENTARY SCHOOL)	MaPamelaLegasp1	ROEL D. BOMER, C.E./RMP	MA. ESTER E. HAMOR
LOC: BRGY. TUGOS, WEST DISTRICT SORSOGON CITY	DRAFTING AIDE	CITY ENGINEER	CITY MAYOR

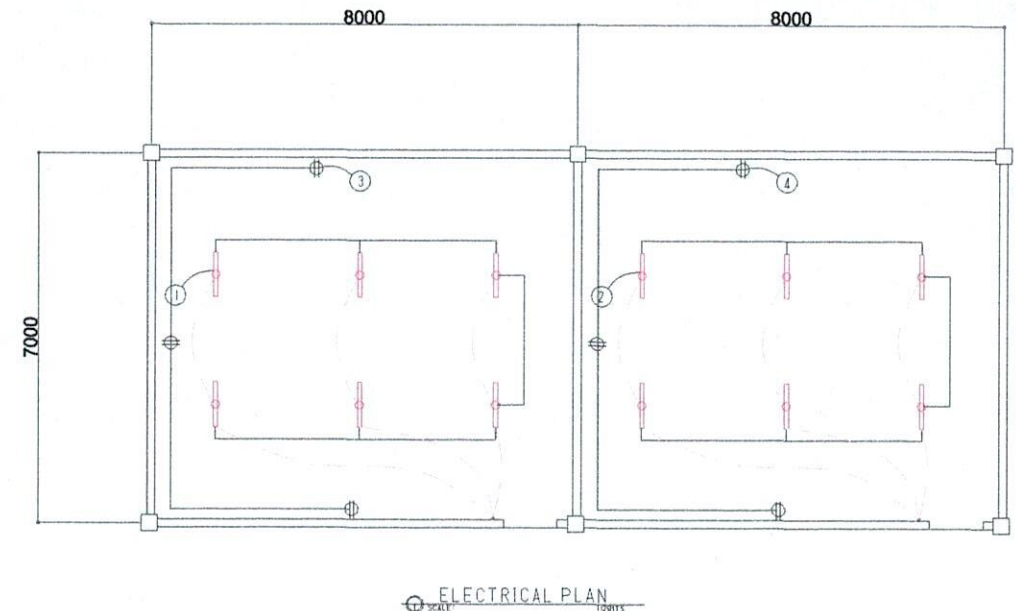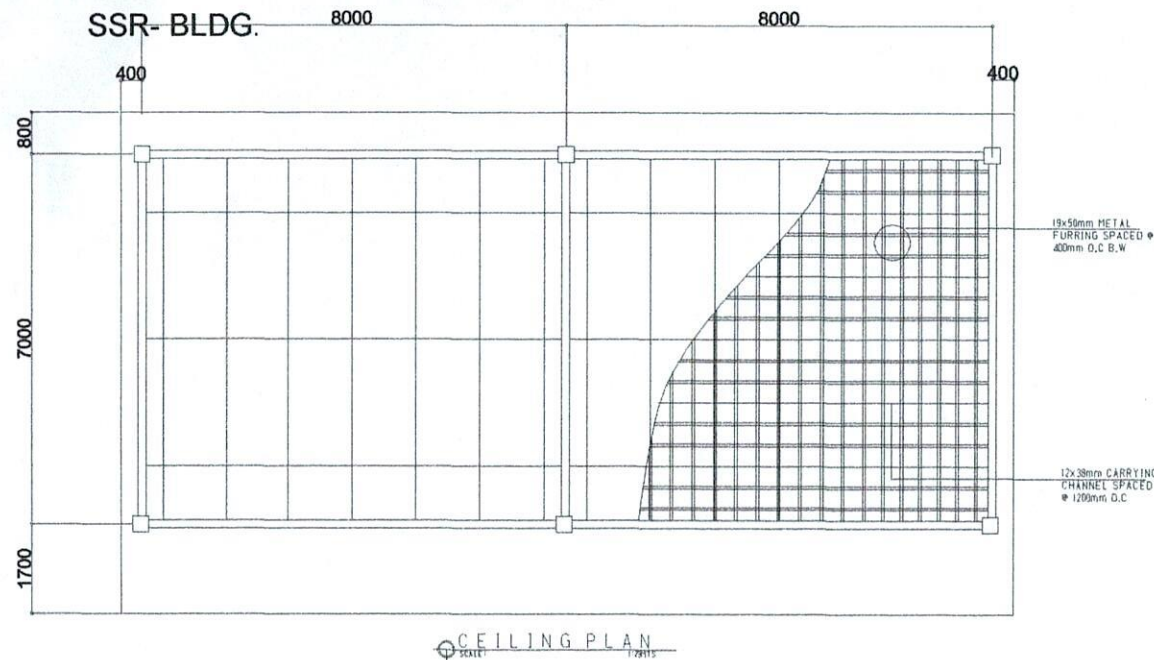

SCHEDULE OF LOADS

CIRCUIT NO.	DESCRIPTION	NO. OF LOADS	VOLTS	WATTS	AMP	SIZE OF WIRE	SIZE OF CONDUIT
1	LIGHTING OUTLET	6	230	600	2.60	2-2.0mm ² THW	15mmØ
2	LIGHTING OUTLET	6	230	600	2.60	2-2.0mm ² THW	15mmØ
3	CONVENIENCE OUTLET	3	230	540	2.34	2-3.5mm ² THW	20mmØ
4	CONVENIENCE OUTLET	3	230	540	2.34	2-3.5mm ² THW	20mmØ
TOTAL					9.88		

ELECTRICAL NOTES

ALL ELECTRICAL WORKS SHALL BE DONE IN ACCORDANCE WITH THE LATEST RULES AND REGULATIONS OF THE PHIL. ELECTRICAL CODE AS WELL AS THE LOCAL AUTHORITY CONCERNED AND THE LOCAL POWER COMPANY.

ALL ELECTRICAL MATERIALS TO BE USED SHALL BE NEED & APPROVED TYPE FOR LOCATION & PURPOSE

MOUNTING HEIGHTS SHALL BE AS FOLLOWS:

- LIGHT CONTROL SWITCH- 1.35M ABOVE FIN. FLR. LINE AT CENTER
- CONVENIENCE OUTLET-ABOVE 1.0M ABOVE FIN. FLR. LINE AT CENTER
- PANEL BOARD- 2.0 M ABOVE FIN. FLR. LINE

ALL ELECTRICAL WORKS SHALL BE UNDER THE DIRECT & IMMEDIATE SUPERVISION OF A DULY LICENSED ELECTRICAL ENGINEER OR REGISTERED MASTER ELECTRICIAN



CITY ENGINEER'S
O F F I C E

PROJECT TITLE:

REPAIR/IMPROV. OF MULTI-PURPOSE HALL
(TUGOS ELEMENTARY SCHOOL)

LOC: BRGY. TUGOS, WEST DISTRICT

SORSOGON CITY

DRAWN BY:

MaPamelaLegaspi

DRAFTING AIDE



RECOMMENDING APPROVAL :

ROEL D. BOMER, C.E./RMP
CITY ENGINEER

APPROVED BY:

MA. ESTER E. HAMOR
CITY MAYOR



ACADEMIC BLDG. 4

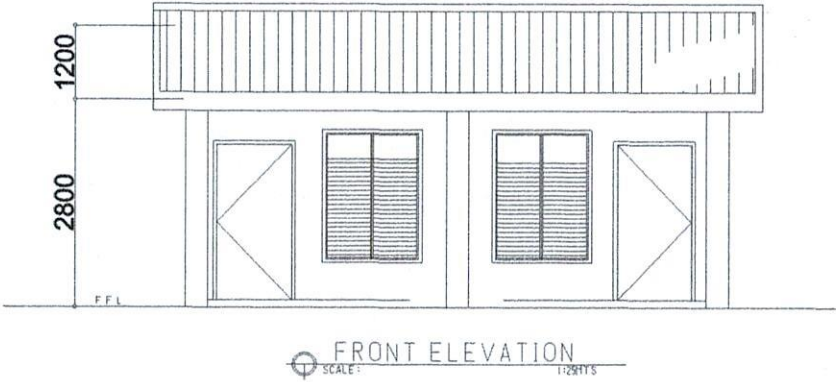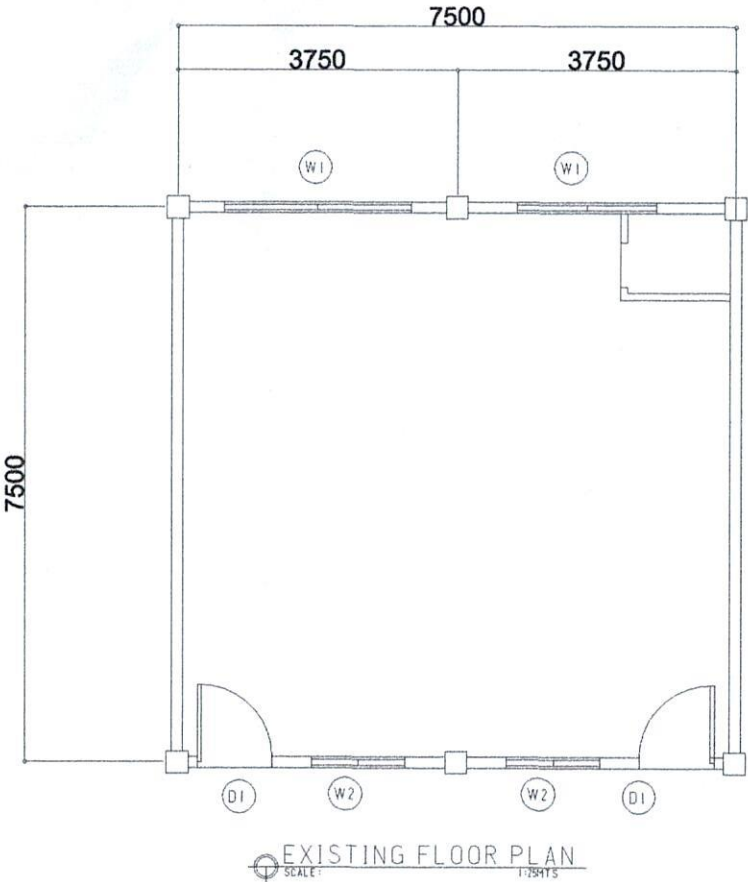

CITY ENGINEER'S
O F F I C E

PROJECT TITLE:	DRAWN BY:	RECOMMENDING APPROVAL :	APPROVED BY:
REPAIR/IMPROV. OF MULTI-PURPOSE HALL (TUGOS ELEMENTARY SCHOOL)			
LOC: BRGY. TUGOS, WEST DISTRICT SORSOGON CITY	Ma Pamela Legaspi DRAFTING AIDE	ROEL D. DOMER, C.E./RMP CITY ENGINEER	MA. ESTER E. HAMOR CITY MAYOR




ACADEMIC BLDG. 4

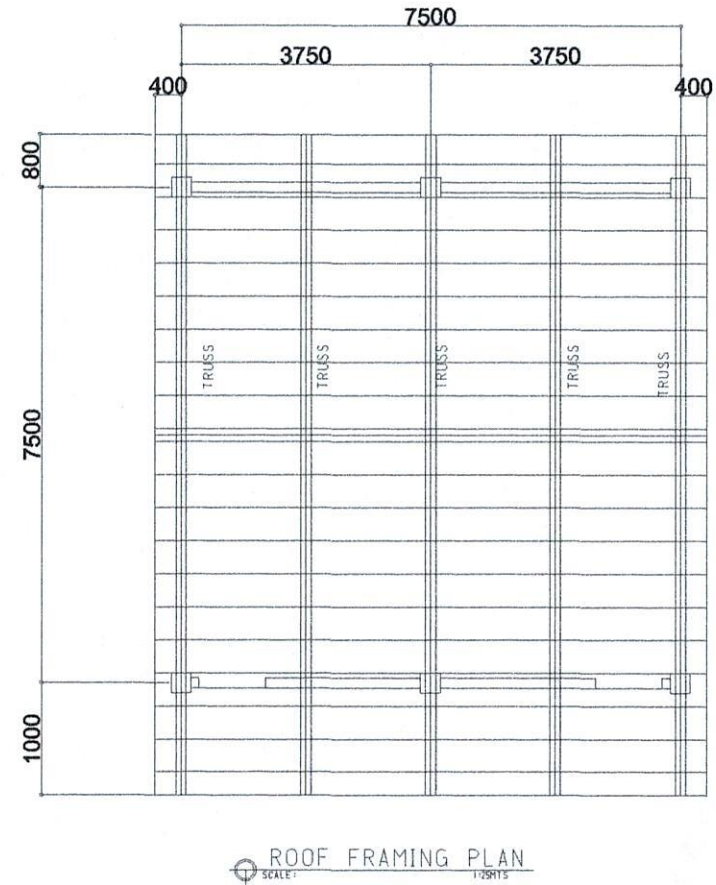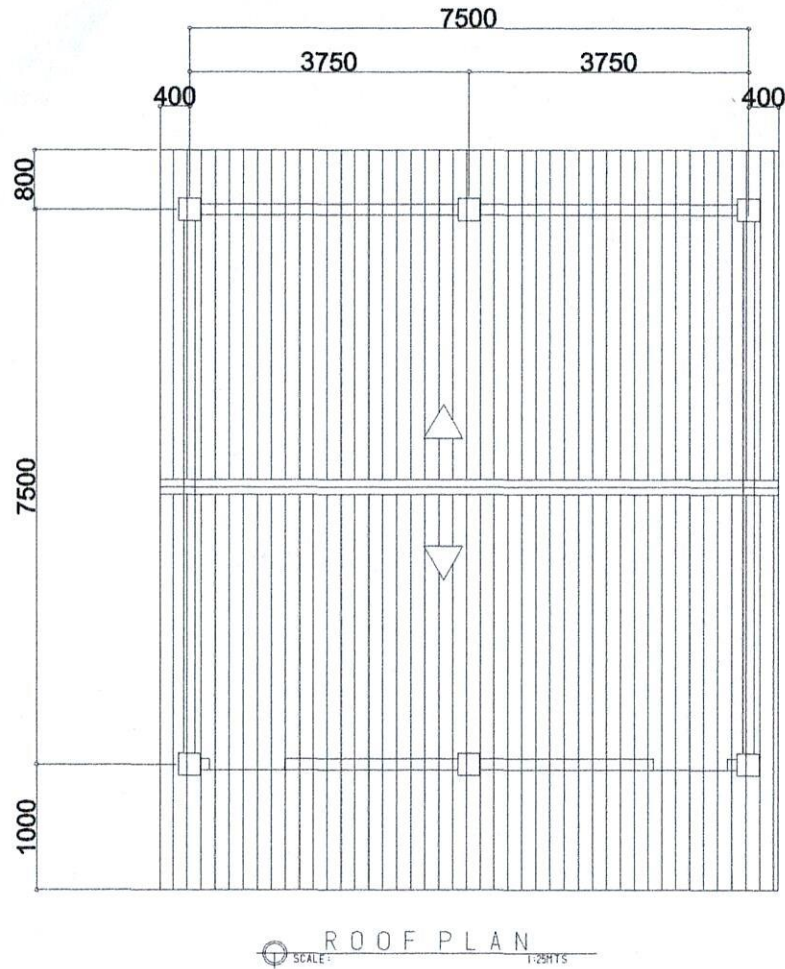

CITY ENGINEER'S
O F F I C E

PROJECT TITLE:	DRAWN BY:	RECOMMENDING APPROVAL :	APPROVED BY:
REPAIR/IMPROV. OF MULTI-PURPOSE HALL (TUGOS ELEMENTARY SCHOOL)			
LOC: BRGY. TUGOS, WEST DISTRICT	MaPamelaLegaspi	ROEL D. BOMER, C.E./RMP	MA. ESVER E. HAMOR
SORSOGON CITY	DRAFTING AIDE	CITY ENGINEER	CITY MAYOR


ACADEMIC BLDG. 4

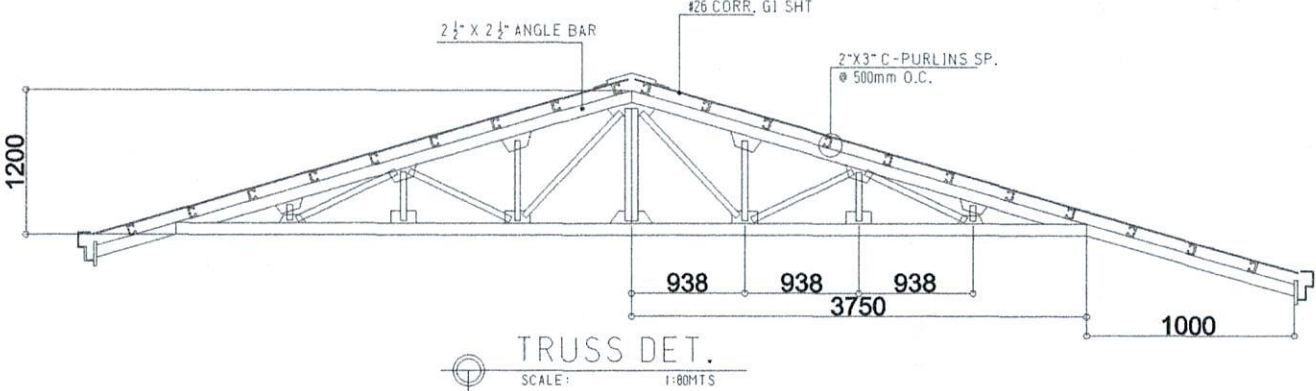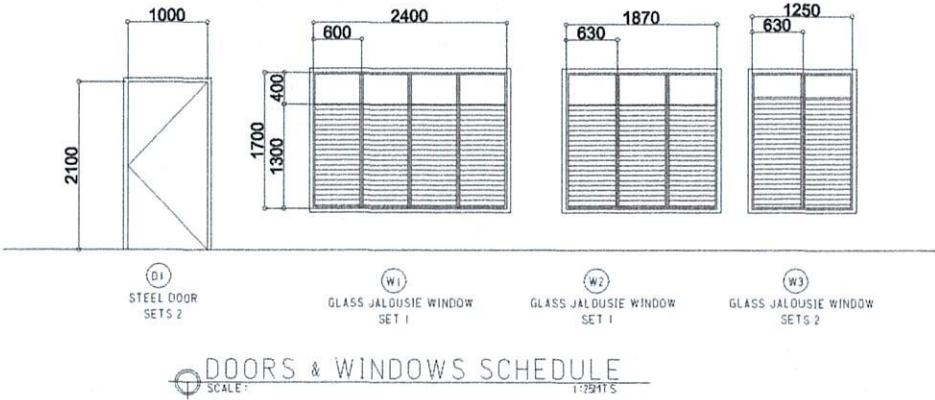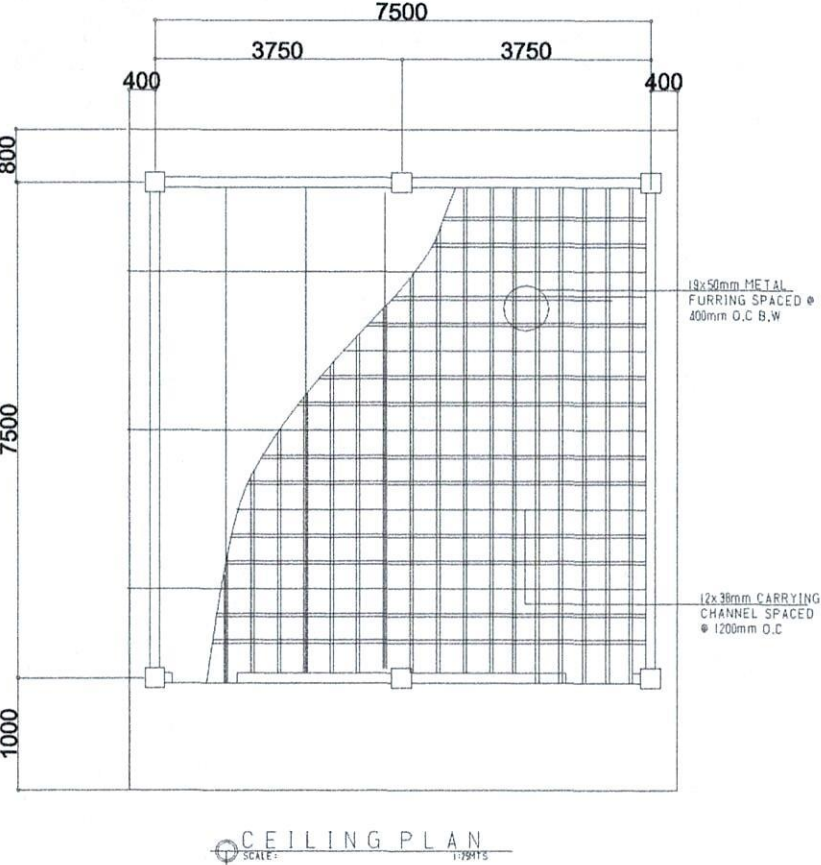

CITY ENGINEER'S
OFFICE

PROJECT TITLE:	DRAWN BY:	RECOMMENDING APPROVAL :	APPROVED BY:
REPAIR/IMPROV. OF MULTI-PURPOSE HALL (TUGOS ELEMENTARY SCHOOL)			
LOC: BRGY. TUGOS, WEST DISTRICT	Ma Pamela Legaspi	ROEL D. DOMER, C.E./RMP	MA. ESTER E. HAMOR
SORSOGON CITY	DRAFTING AIDE	CITY ENGINEER	CITY MAYOR

ACADEMIC BLDG. 4

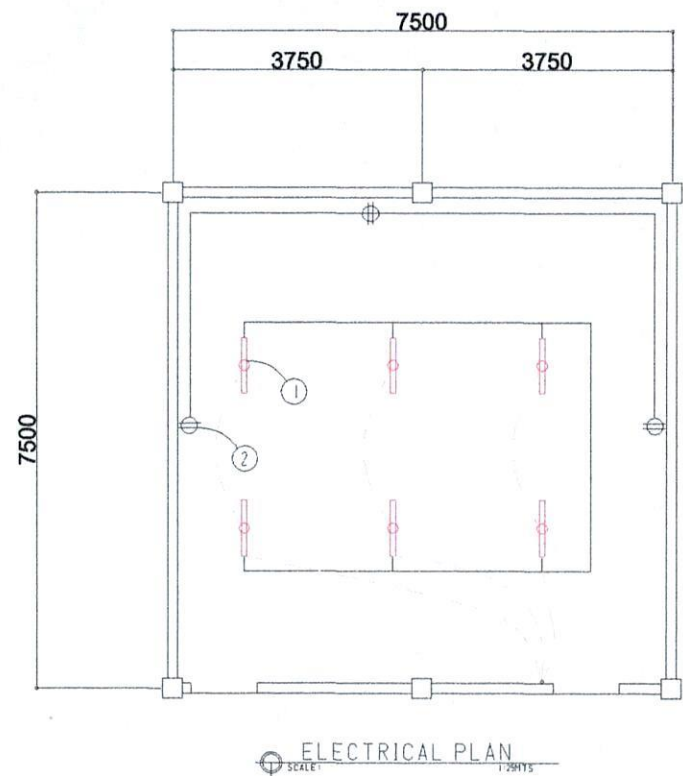

SCHEDULE OF LOADS							
CIRCUIT NO.	DESCRIPTION	NO. OF LOADS	VOLTS	WATTS	AMP	SIZE OF WIRE	SIZE OF CONDUIT
1	LIGHTING OUTLET	6	230	600	2.60	2-2.0mm ² THW	15mmØ
2	CONVENIENCE OUTLET	3	230	540	2.34	2-3.5mm ² THW	20mmØ
TOTAL					4.94		

ELECTRICAL NOTES

ALL ELECTRICAL WORKS SHALL BE DONE IN ACCORDANCE WITH THE LATEST RULES AND REGULATIONS OF THE PHIL. ELECTRICAL CODE AS WELL AS THE LOCAL AUTHORITY CONCERNED AND THE LOCAL POWER COMPANY.

ALL ELECTRICAL MATERIALS TO BE USED SHALL BE NEED & APPROVED TYPE FOR LOCATION & PURPOSE

MOUNTING HEIGHTS SHALL BE AS FOLLOWS:

- a. LIGHT CONTROL SWITCH- 1.35M ABOVE FIN. FLR. LINE AT CENTER
- b. CONVENIENCE OUTLET-ABOVE 1.0M ABOVE FIN. FLR. LINE AT CENTER
- c. PANEL BOARD- 2.0 M ABOVE FIN. FLR. LINE


ALL ELECTRICAL WORKS SHALL BE UNDER THE DIRECT & IMMEDIATE SUPERVISION OF A DULY LICENSED ELECTRICAL ENGINEER OR REGISTERED MASTER ELECTRICIAN




CITY ENGINEER'S
O F F I C E

PROJECT TITLE:	DRAWN BY:	RECOMMENDING APPROVAL :	APPROVED BY:
REPAIR/IMPROV. OF MULTI-PURPOSE HALL (TUGOS ELEMENTARY SCHOOL)			
LOC: BRGY. TUGOS, WEST DISTRICT	MaPamela Legaspi	ROEL D. DOMER, C.E./RMP	MA. ESTER E. HAMOR
SORSOGON CITY	DRAFTING AIDE	CITY ENGINEER	CITY MAYOR


ACADEMIC BLDG. 1

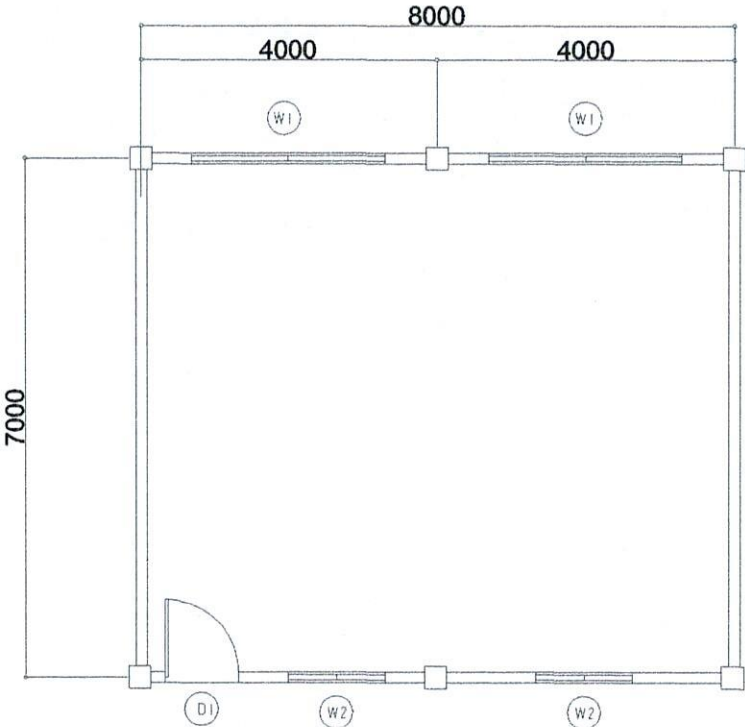

EXISTING FLOOR PLAN
SCALE: 1:250

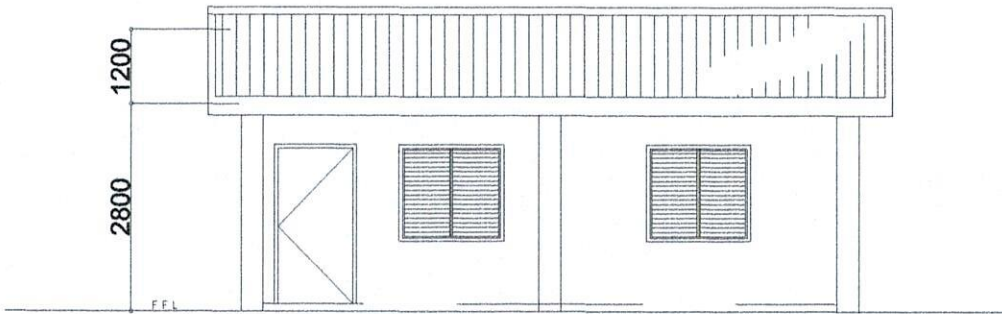

FRONT ELEVATION
SCALE: 1:250

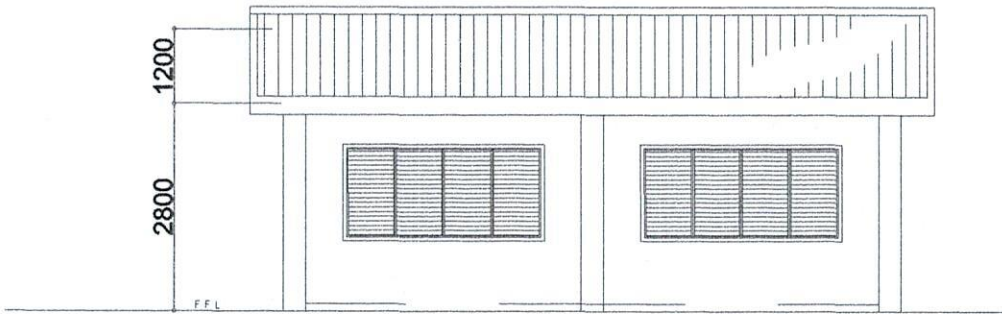


REAR ELEVATION
SCALE: 1:250




CITY ENGINEER'S
O F F I C E

PROJECT TITLE:	DRAWN BY:	RECOMMENDING APPROVAL :	APPROVED BY:
REPAIR/IMPROV. OF MULTI-PURPOSE HALL (TUGOS ELEMENTARY SCHOOL)			
LOC: BRGY. TUGOS, WEST DISTRICT	MaPamelaLegaspi	ROEL D. DOMER, C.E./RMP	MA. ESTER E. HAMOR
SORSOGON CITY	DRAFTING AIDE	CITY ENGINEER	CITY MAYOR

ACADEMIC BLDG. 1

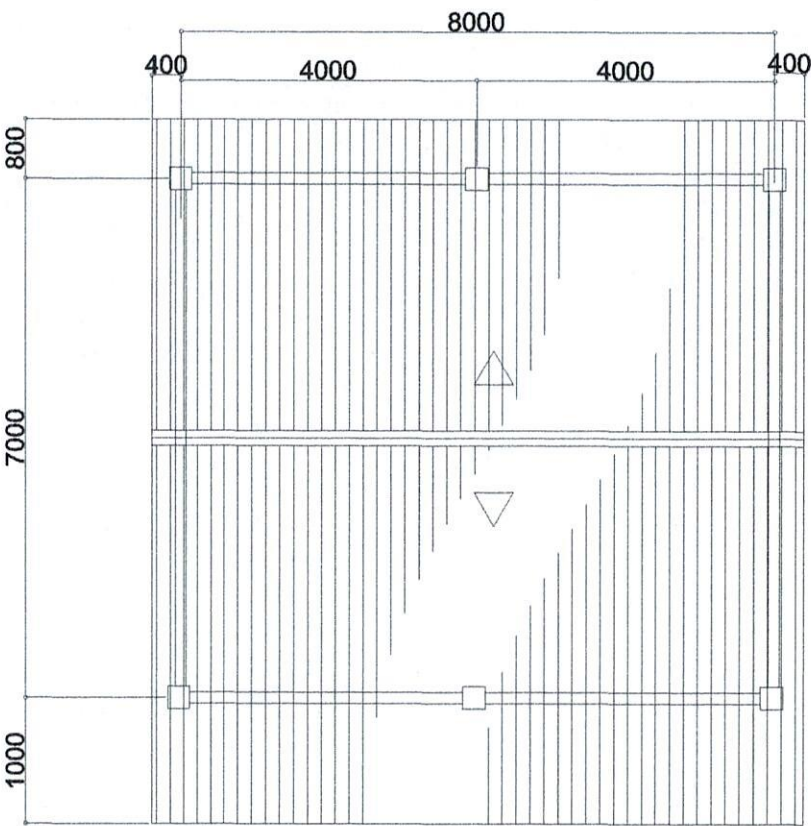

ROOF PLAN
SCALE: 1/250

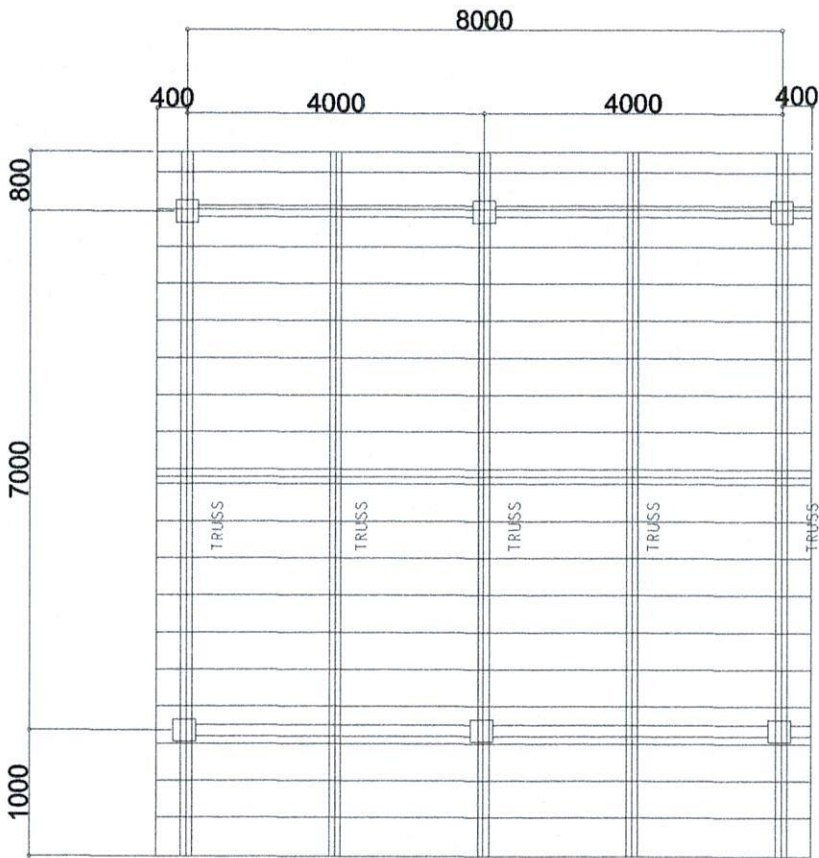


ROOF FRAMING PLAN
SCALE: 1/250




CITY ENGINEER'S
OFFICE

PROJECT TITLE:	DRAWN BY:	RECOMMENDING APPROVAL :	APPROVED BY:
REPAIR/IMPROV. OF MULTI-PURPOSE HALL (TUGOS ELEMENTARY SCHOOL)			
LOC: BRGY. TUGOS, WEST DISTRICT	Ma Pamela Legaspi	ROEL D. DOMER, C.E./RMP	MA. ESTER E. HAMOR
SORSOGON CITY	DRAFTING AIDE	CITY ENGINEER	CITY MAYOR


ACADEMIC BLDG. 1

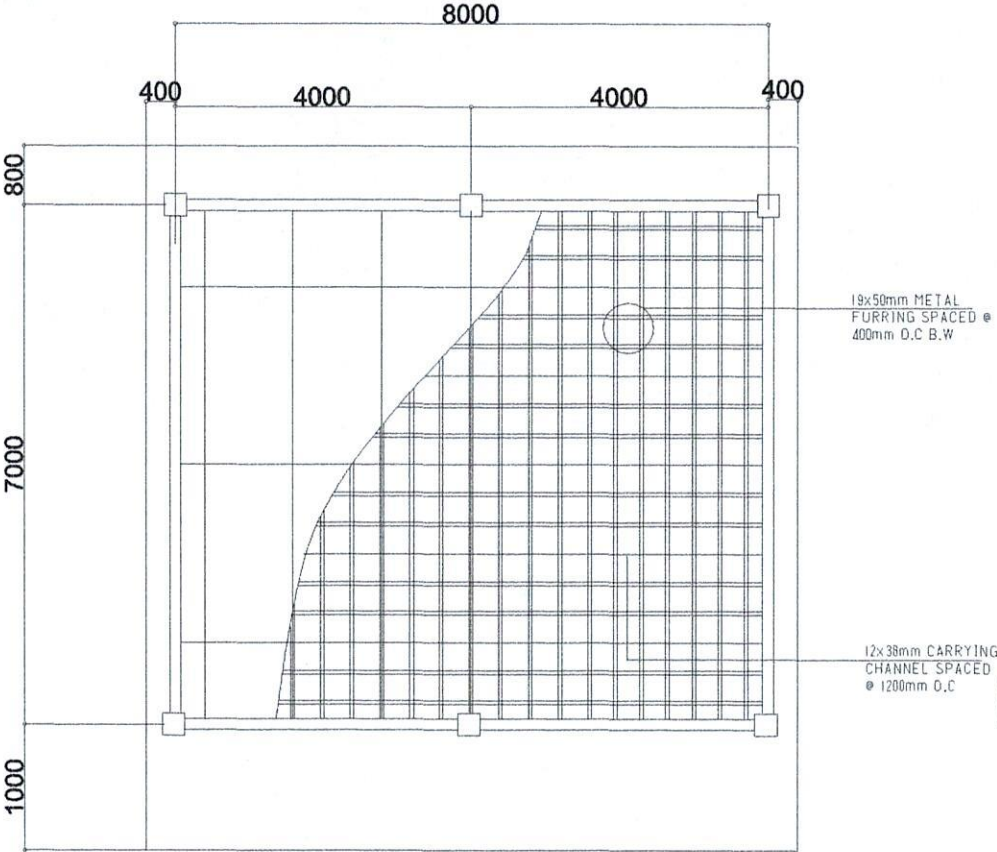

CEILING PLAN
SCALE: 1:25MTS

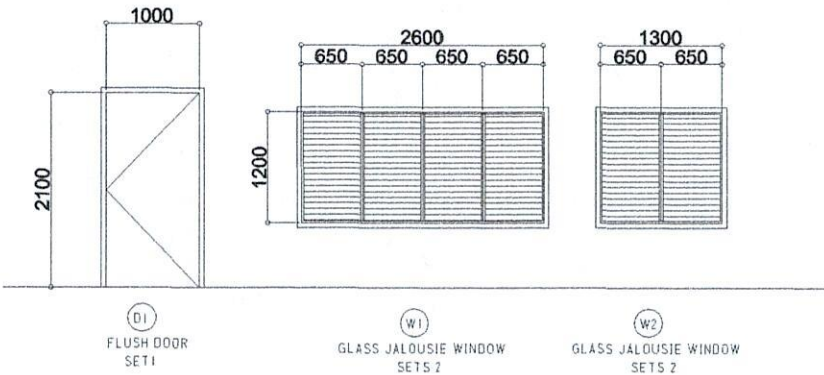

DOORS & WINDOWS SCHEDULE
SCALE: 1:25MTS

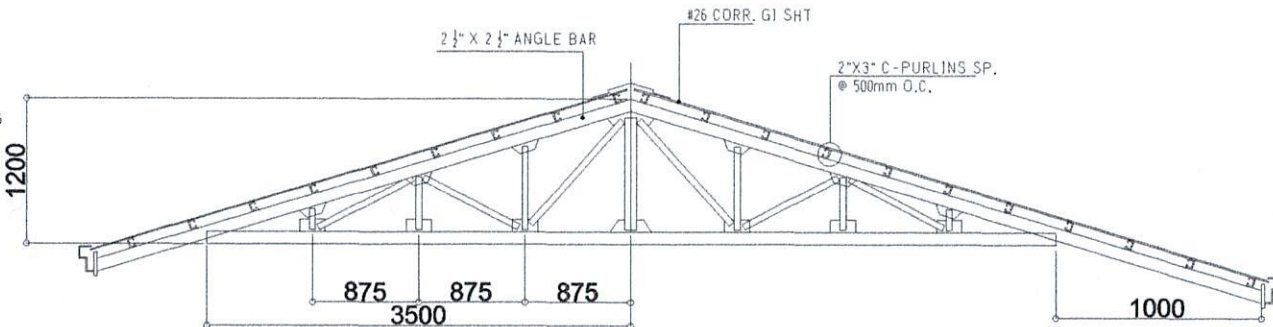


TRUSS DET.
SCALE: 1:80MTS



CITY ENGINEER'S
O F F I C E

PROJECT TITLE:	DRAWN BY:	RECOMMENDING APPROVAL :	APPROVED BY:
REPAIR/IMPROV. OF MULTI-PURPOSE HALL (TUGOS ELEMENTARY SCHOOL)			
LOC: BRGY. TUGOS, WEST DISTRICT	MaPamela Legaspi	ROEL D. DOMER, C.E./RMP	MA. ESTER E. HAMOR
SORSOGON CITY	DRAFTING AIDE	CITY ENGINEER	CITY MAYOR

ACADEMIC BLDG. 1

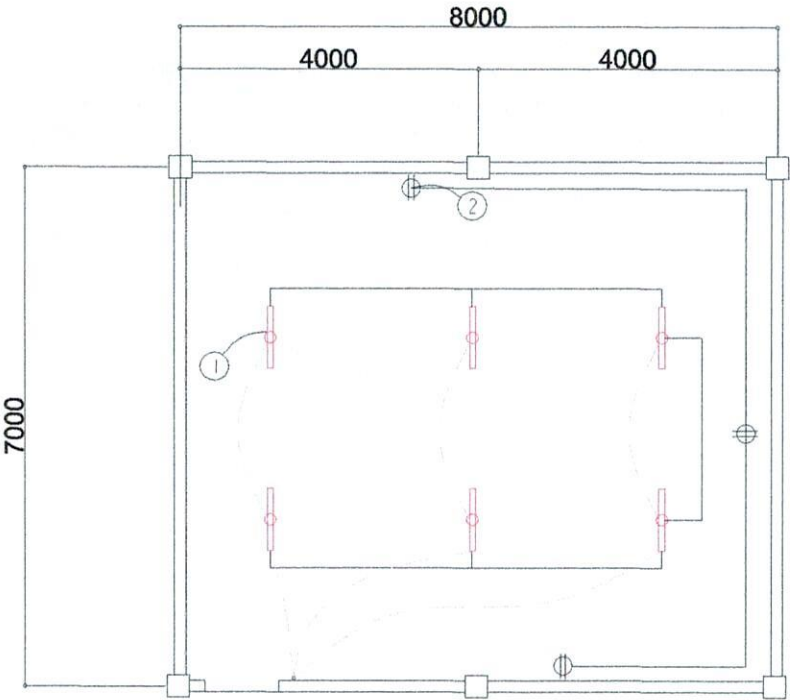

SCHEDULE OF LOADS							
CIRCUIT NO.	DESCRIPTION	NO. OF LOADS	VOLTS	WATTS	AMP	SIZE OF WIRE	SIZE OF CONDUIT
1	LIGHTING OUTLET	6	230	600	2.60	2-2.0mm ² THW	15mmØ
2	CONVENIENCE OUTLET	3	230	540	2.34	2-3.5mm ² THW	20mmØ
TOTAL					4.94		

ELECTRICAL NOTES

ALL ELECTRICAL WORKS SHALL BE DONE IN ACCORDANCE WITH THE LATEST RULES AND REGULATIONS OF THE PHIL. ELECTRICAL CODE AS WELL AS THE LOCAL AUTHORITY CONCERNED AND THE LOCAL POWER COMPANY.

ALL ELECTRICAL MATERIALS TO BE USED SHALL BE NEED & APPROVED TYPE FOR LOCATION & PURPOSE

MOUNTING HEIGHTS SHALL BE AS FOLLOWS:

- a. LIGHT CONTROL SWITCH- 1.35M ABOVE FIN. FLR. LINE AT CENTER
- b. CONVENIENCE OUTLET-ABOVE 1.0M ABOVE FIN. FLR. LINE AT CENTER
- c. PANEL BOARD- 2.0 M ABOVE FIN. FLR. LINE




ALL ELECTRICAL WORKS SHALL BE UNDER THE DIRECT & IMMEDIATE SUPERVISION OF A DULY LICENSED ELECTRICAL ENGINEER OR REGISTERED MASTER ELECTRICIAN



CITY ENGINEER'S
O F F I C E

PROJECT TITLE:	DRAWN BY:	RECOMMENDING APPROVAL :	APPROVED BY:
REPAIR/IMPROV. OF MULTI-PURPOSE HALL (TUGOS ELEMENTARY SCHOOL)			
LOC: BRGY. TUGOS, WEST DISTRICT	MaPamelaLegaspi	ROEL D. DOMEN, C.E./RMP	MA. ESTER E. HAMOR
SORSOGON CITY	DRAFTING AIDE	CITY ENGINEER	CITY MAYOR



BLSB

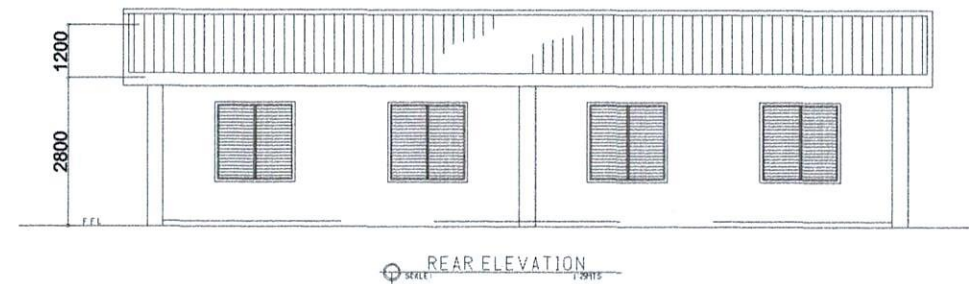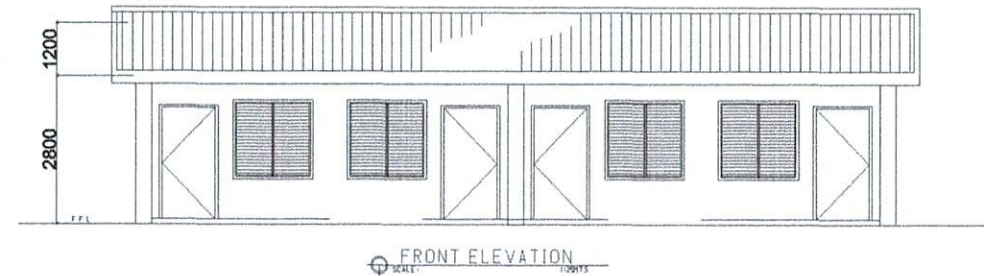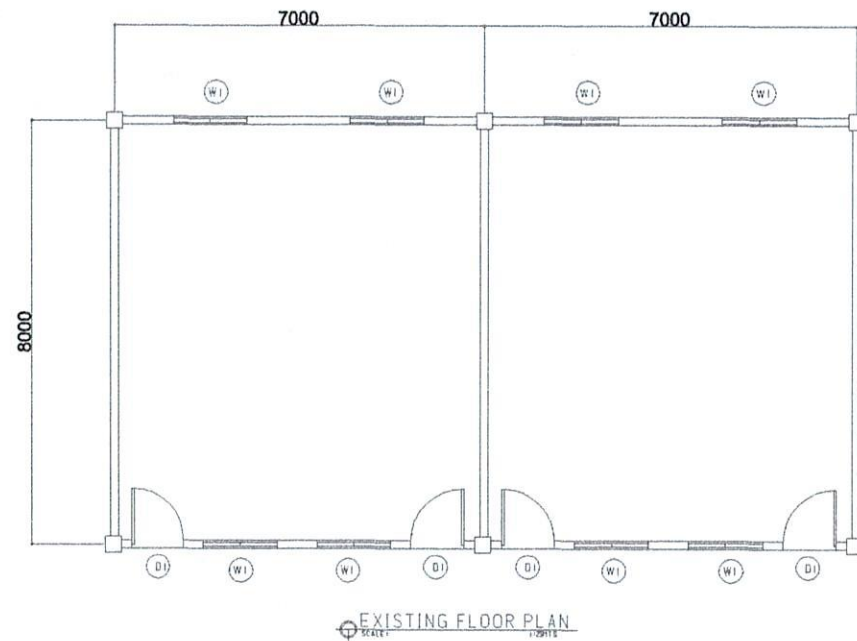

CITY ENGINEER'S
O F F I C E

PROJECT TITLE:	DRAWN BY:	RECOMMENDING APPROVAL :	APPROVED BY:
REPAIR/IMPROV. OF MULTI-PURPOSE HALL (TUGOS ELEMENTARY SCHOOL)			
LOC: BRGY. TUGOS, WEST DISTRICT	MaPamelaLegaspi	ROEL D. DOMER, C.E./RMP	MA. ESTER E. HAMOR
SORSOGON CITY	DRAFTING AIDE	CITY ENGINEER	CITY MAYOR

BLSB

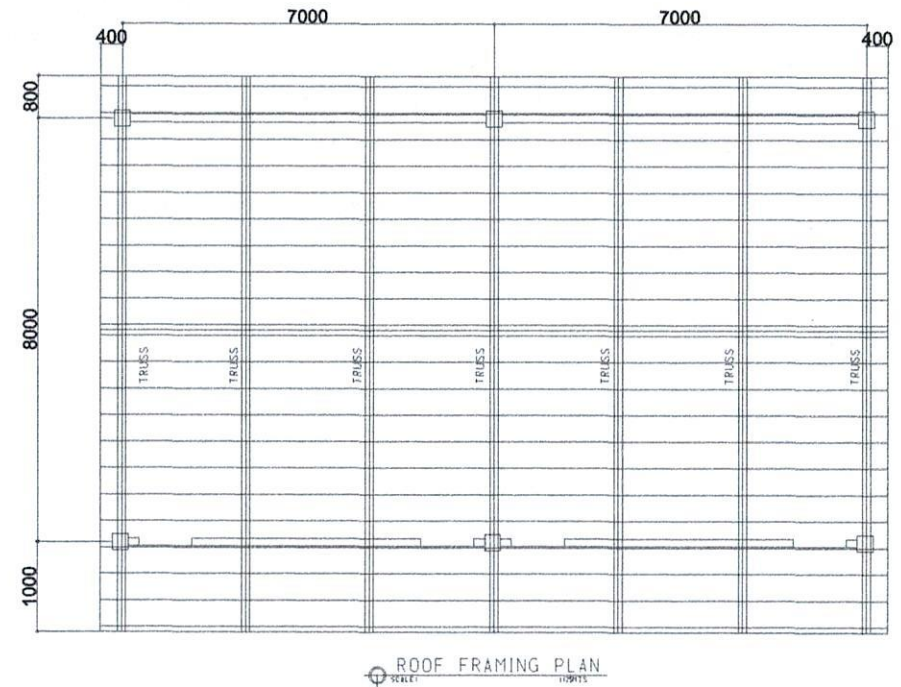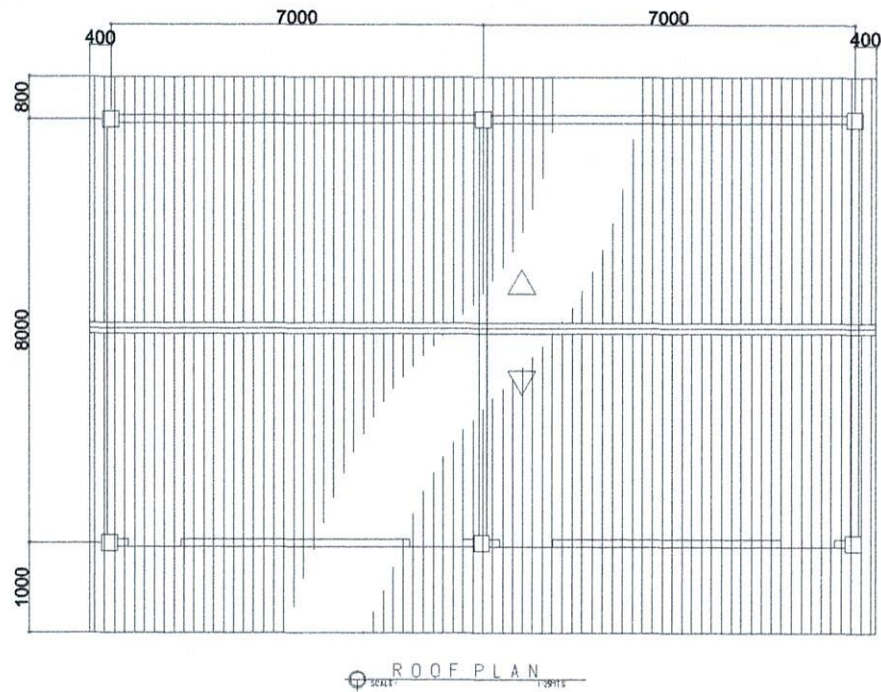

CITY ENGINEER'S
O F F I C E

PROJECT TITLE:

REPAIR/IMPROV. OF MULTI-PURPOSE HALL
(TUGOS ELEMENTARY SCHOOL)

LOC: BRGY. TUGOS, WEST DISTRICT
SORSOGON CITY

DRAWN BY:

Ma Pamela Legaspi
DRAFTING AIDE




RECOMMENDING APPROVAL:

ROEL D. DOMER, C.E./RMP
CITY ENGINEER

APPROVED BY:

MA. ESTER E. HAMOR
CITY MAYOR

BLSB

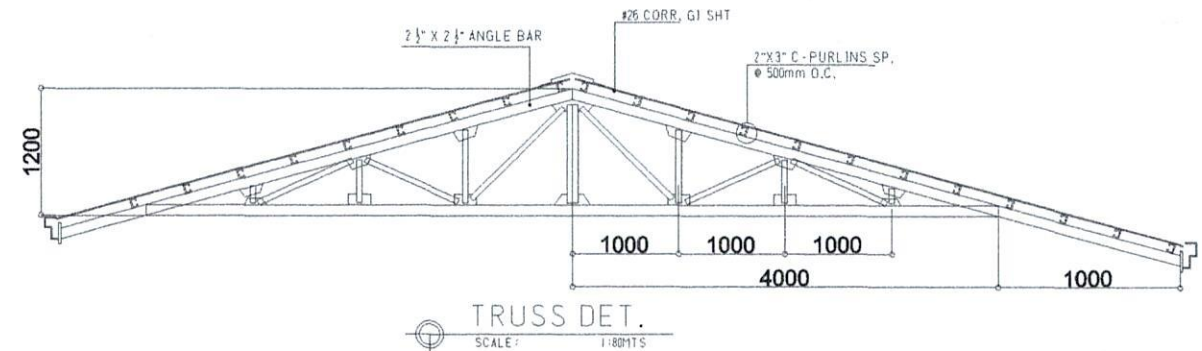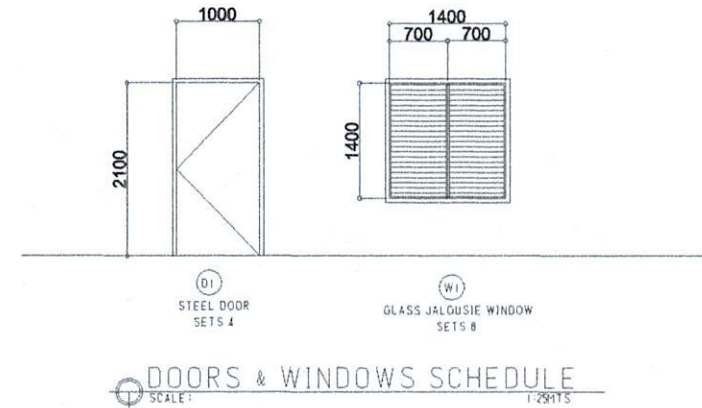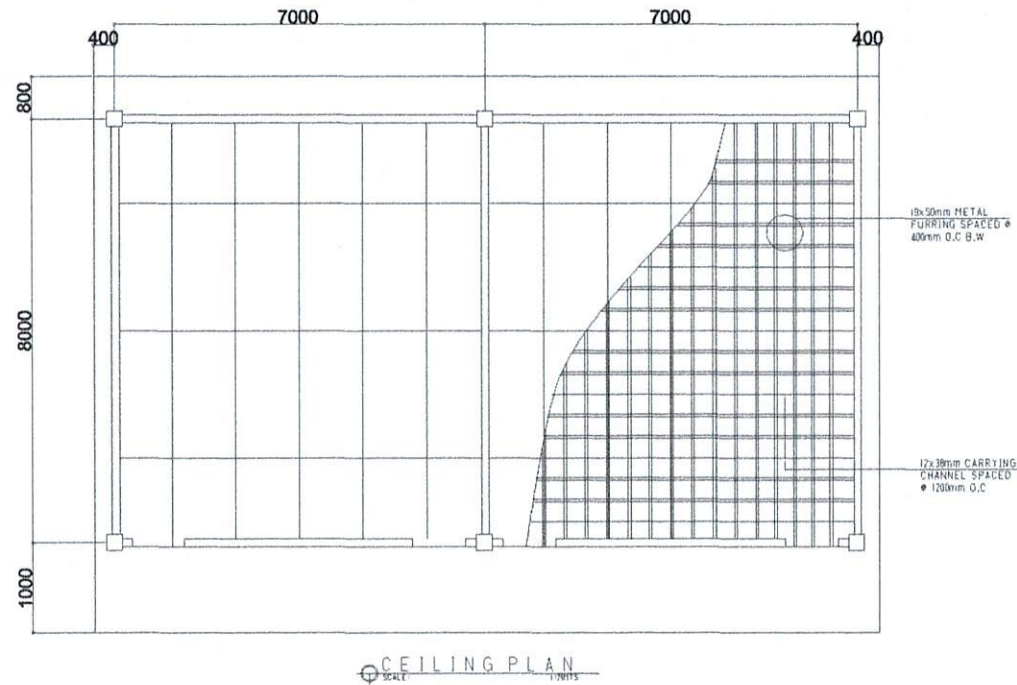

CITY ENGINEER'S
OFFICE

PROJECT TITLE:

REPAIR/IMPROV. OF MULTI-PURPOSE HALL
(TUGOS ELEMENTARY SCHOOL)

LOC: BRGY. TUGOS, WEST DISTRICT

SORSOGON CITY

DRAWN BY:

MaPamela Legaspi

DRAFTING AIDE

RECOMMENDING APPROVAL:

ROEL D. DOMER, C.E./RMP


CITY ENGINEER

APPROVED BY:

MA. ESTER E. HAMOR

CITY MAYOR

BLSB

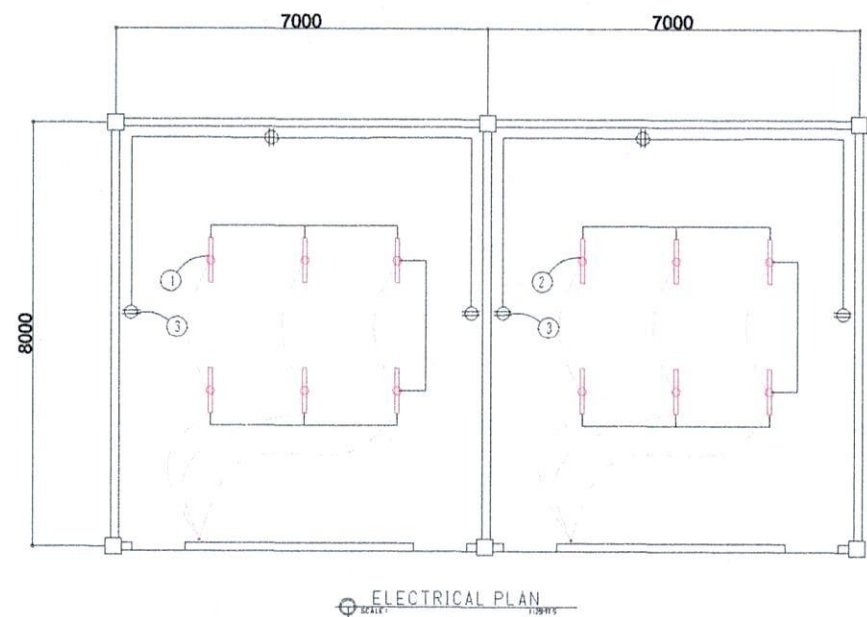

SCHEDULE OF LOADS							
CIRCUIT NO.	DESCRIPTION	NO. OF LOADS	VOLTS	WATTS	AMP	SIZE OF WIRE	SIZE OF CONDUIT
1	LIGHTING OUTLET	6	230	600	2.60	2-2.0mm² THW	15mmØ
2	LIGHTING OUTLET	6	230	600	2.60	2-2.0mm² THW	15mmØ
3	CONVENIENCE OUTLET	3	230	540	2.34	2-3.5mm² THW	20mmØ
4	CONVENIENCE OUTLET	3	230	540	2.34	2-3.5mm² THW	20mmØ
TOTAL					9.88		

ELECTRICAL NOTES

ALL ELECTRICAL WORKS SHALL BE DONE IN ACCORDANCE WITH THE LATEST RULES AND REGULATIONS OF THE PHIL. ELECTRICAL CODE AS WELL AS THE LOCAL AUTHORITY CONCERNED AND THE LOCAL POWER COMPANY.

ALL ELECTRICAL MATERIALS TO BE USED SHALL BE NEED & APPROVED TYPE FOR LOCATION & PURPOSE

MOUNTING HEIGHTS SHALL BE AS FOLLOWS:

- a. LIGHT CONTROL SWITCH- 1.35M ABOVE FIN. FLR. LINE AT CENTER
- b. CONVENIENCE OUTLET-ABOVE 1.0M ABOVE FIN. FLR. LINE AT CENTER
- c. PANEL BOARD- 2.0 M ABOVE FIN. FLR. LINE




ALL ELECTRICAL WORKS SHALL BE UNDER THE DIRECT & IMMEDIATE SUPERVISION OF A DULY LICENSED ELECTRICAL ENGINEER OR REGISTERED MASTER ELECTRICIAN



CITY ENGINEER'S
O F F I C E

PROJECT TITLE:	DRAWN BY:	RECOMMENDING APPROVAL :	APPROVED BY:
REPAIR/IMPROV. OF MULTI-PURPOSE HALL (TUGOS ELEMENTARY SCHOOL)			
LOC: BRGY. TUGOS, WEST DISTRICT	MaPamela Legaspi	ROEL D. DOMER, C.E./RMP	MA. ESTER E. HAMOR
SORSOGON CITY	DRAFTING AIDE	CITY ENGINEER	CITY MAYOR


ACADEMIC BLDG. 3

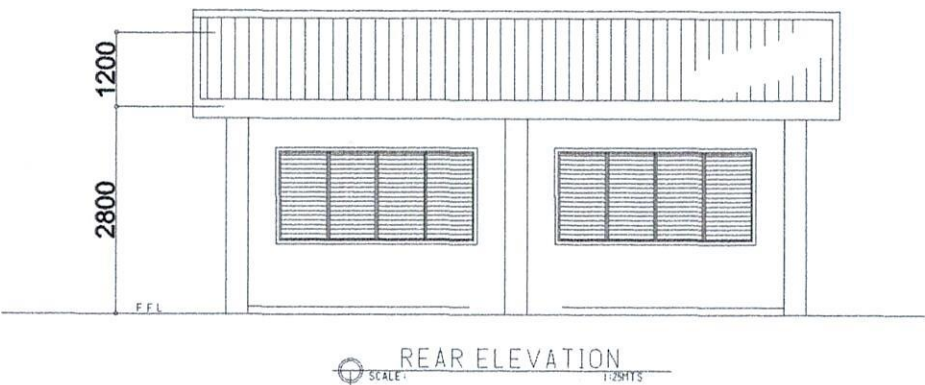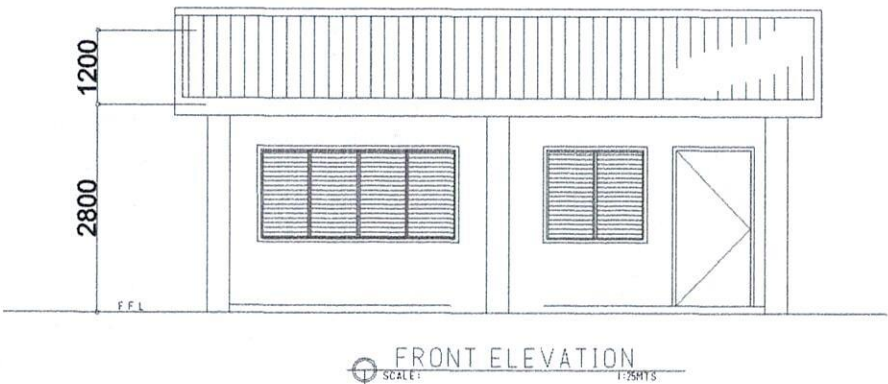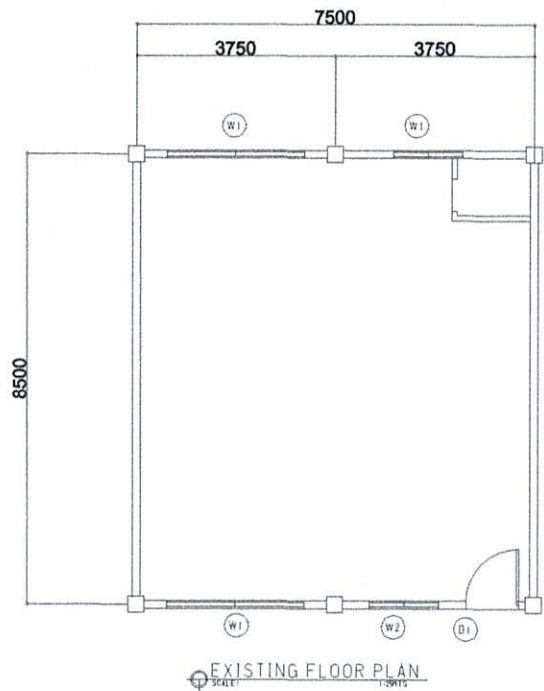


CITY ENGINEER'S
O F F I C E

PROJECT TITLE:	DRAWN BY:	RECOMMENDING APPROVAL :	APPROVED BY:
REPAIR/IMPROV. OF MULTI-PURPOSE HALL (TUGOS ELEMENTARY SCHOOL)			
LOC: BRGY. TUGOS, WEST DISTRICT SORSOGON CITY	MaPamelaLegaspi DRAFTING AIDE	ROEL D. DOMER, C.E./RMP CITY ENGINEER	MA. ESTHER E. HAMOR CITY MAYOR


ACADEMIC BLDG. 3

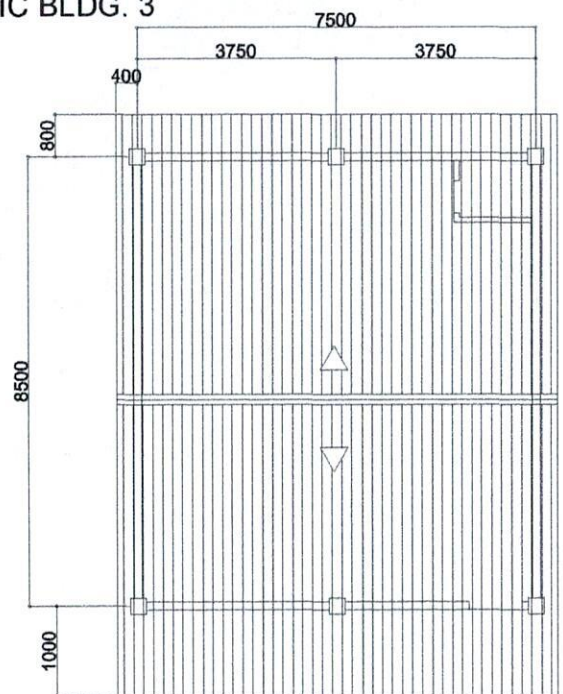


ROOF PLAN
SCALE: 1/8"=1'-0"

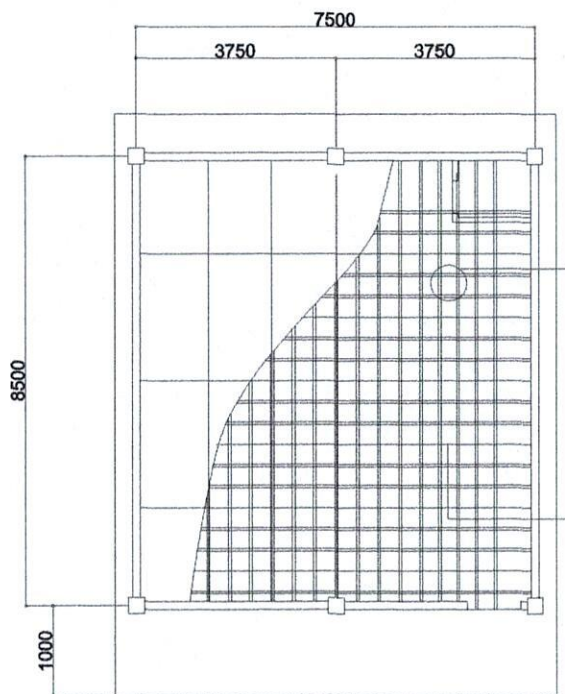

CEILING PLAN
SCALE: 1/8"=1'-0"

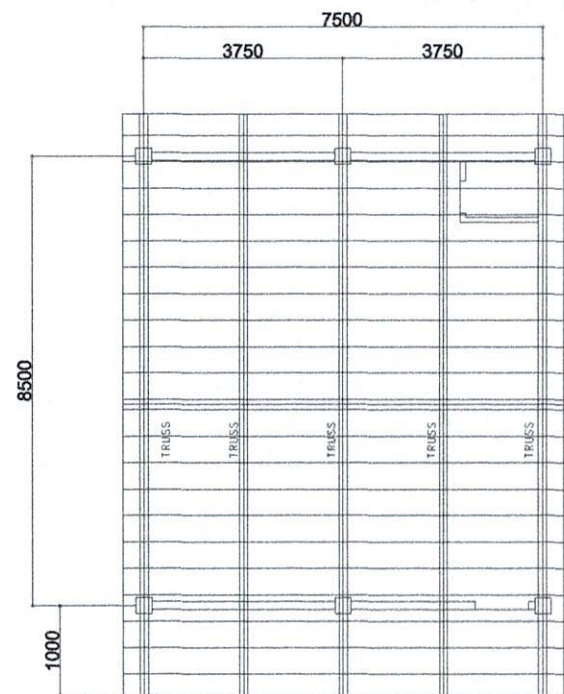

ROOF FRAMING PLAN
SCALE: 1/8"=1'-0"

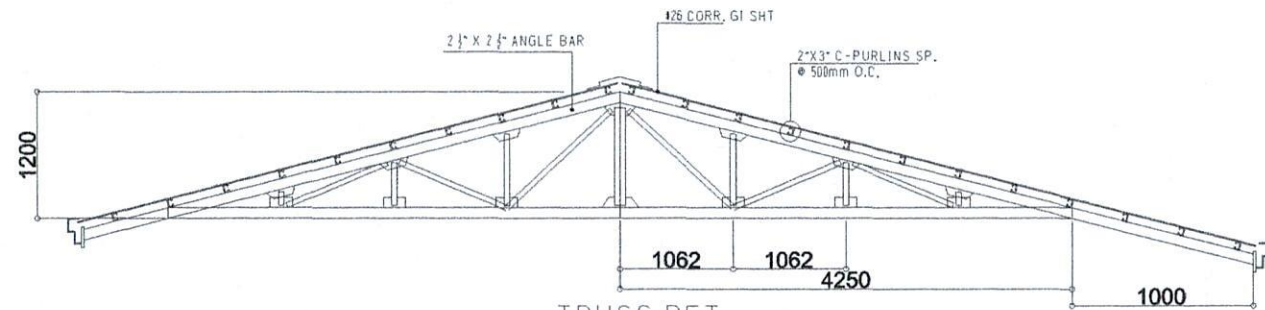


TRUSS DET.
SCALE: 1/8"=1'-0"



CITY ENGINEER'S
OFFICE

PROJECT TITLE:	DRAWN BY:	RECOMMENDING APPROVAL :	APPROVED BY:
REPAIR/IMPROV. OF MULTI-PURPOSE HALL (TUGOS ELEMENTARY SCHOOL)			
LOC: BRGY. TUGOS, WEST DISTRICT	MaPamela Legaspi	ROEL D. BOMER, C.E./RMP	MAURICIO E. HAMOR
SORSOGON CITY	DRAFTING AIDE	CITY ENGINEER	CITY MAYOR

ACADEMIC BLDG. 3

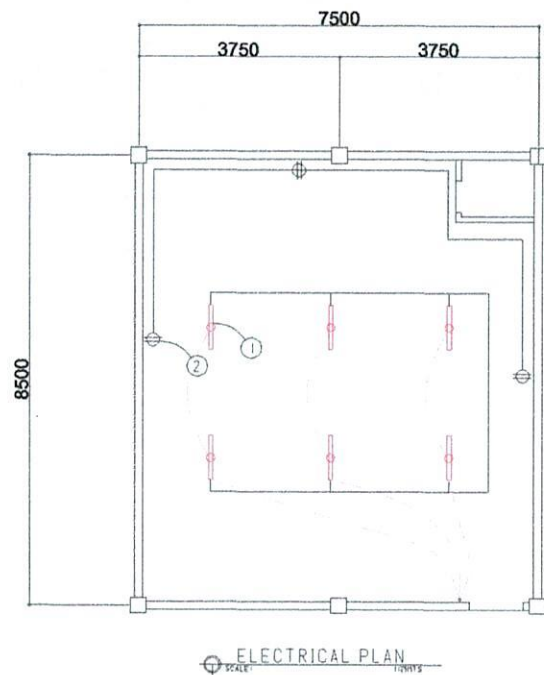

SCHEDULE OF LOADS							
CIRCUIT NO.	DESCRIPTION	NO. OF LOADS	VOLTS	WATTS	AMP	SIZE OF WIRE	SIZE OF CONDUIT
1	LIGHTING OUTLET	6	230	600	2.60	2-2.0mm² THW	15mmØ
2	CONVENIENCE OUTLET	3	230	540	2.34	2-3.5mm² THW	20mmØ
TOTAL					4.94		

ELECTRICAL NOTES

ALL ELECTRICAL WORKS SHALL BE DONE IN ACCORDANCE WITH THE LATEST RULES AND REGULATIONS OF THE PHIL. ELECTRICAL CODE AS WELL AS THE LOCAL AUTHORITY CONCERNED AND THE LOCAL POWER COMPANY.

ALL ELECTRICAL MATERIALS TO BE USED SHALL BE NEED & APPROVED TYPE FOR LOCATION & PURPOSE

- MOUNTING HEIGHTS SHALL BE AS FOLLOWS:
- a. LIGHT CONTROL SWITCH- 1.35M ABOVE FIN. FLR. LINE AT CENTER
 - b. CONVENIENCE OUTLET-ABOVE 1.0M ABOVE FIN. FLR. LINE AT CENTER
 - c. PANEL BOARD- 2.0 M ABOVE FIN. FLR. LINE




ALL ELECTRICAL WORKS SHALL BE UNDER THE DIRECT & IMMEDIATE SUPERVISION OF A DULY LICENSED ELECTRICAL ENGINEER OR REGISTERED MASTER ELECTRICIAN



CITY ENGINEER'S
O F F I C E


PROJECT TITLE:	DRAWN BY:	RECOMMENDING APPROVAL :	APPROVED BY:
REPAIR/IMPROV. OF MULTI-PURPOSE HALL (TUGOS ELEMENTARY SCHOOL)			
LOC: BRGY. TUGOS, WEST DISTRICT	MaPamela Legaspi	ROEL D. DOMER, C.E./RMP	MA. ESTER E. HAMOR
SORSOGON CITY	DRAFTING AIDE	CITY ENGINEER	CITY MAYOR

PRINCIPAL OFFICE

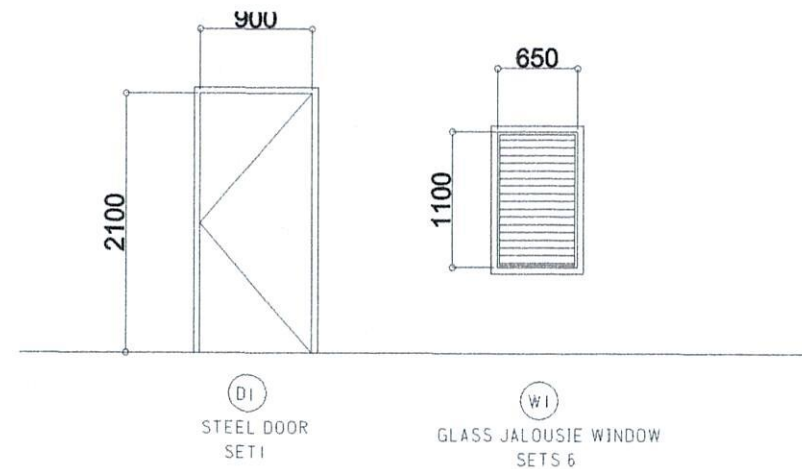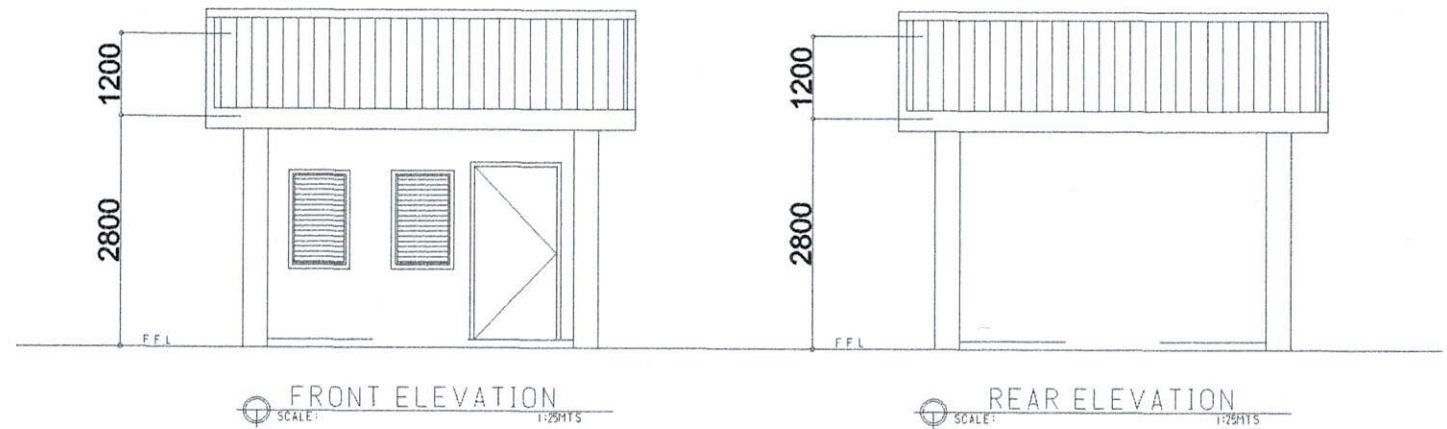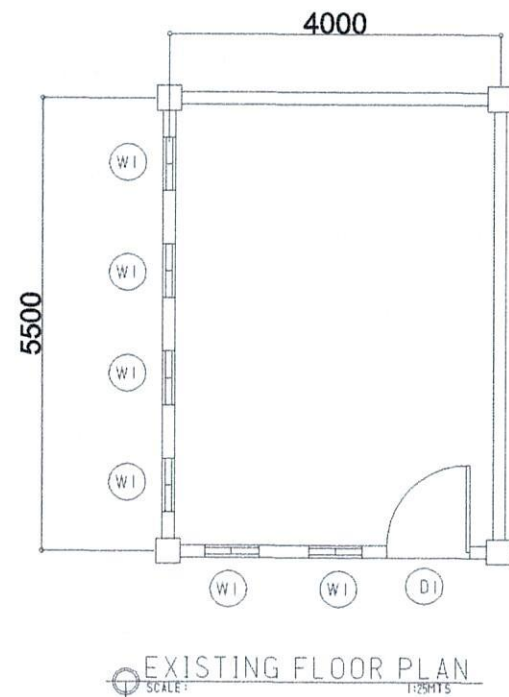


CITY ENGINEER'S
O F F I C E


PROJECT TITLE:	DRAWN BY:	RECOMMENDING APPROVAL :	APPROVED BY:
REPAIR/IMPROV. OF MULTI-PURPOSE HALL (TUGOS ELEMENTARY SCHOOL)			
LOC: BRGY. TUGOS, WEST DISTRICT	Ma Pamela Legaspi	ROEL D. DOMER, C.E./RMP	MA. ESTER E. HAMOR
SORSOGON CITY	DRAFTING AIDE	CITY ENGINEER	CITY MAYOR

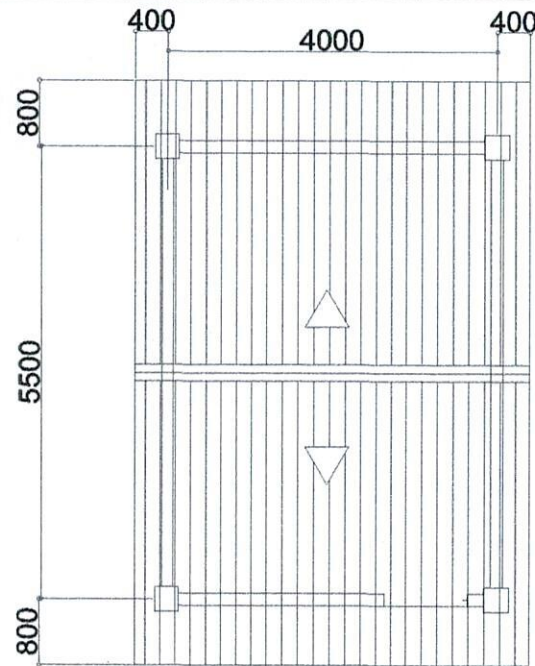

ROOF PLAN
SCALE: 1:25HTS

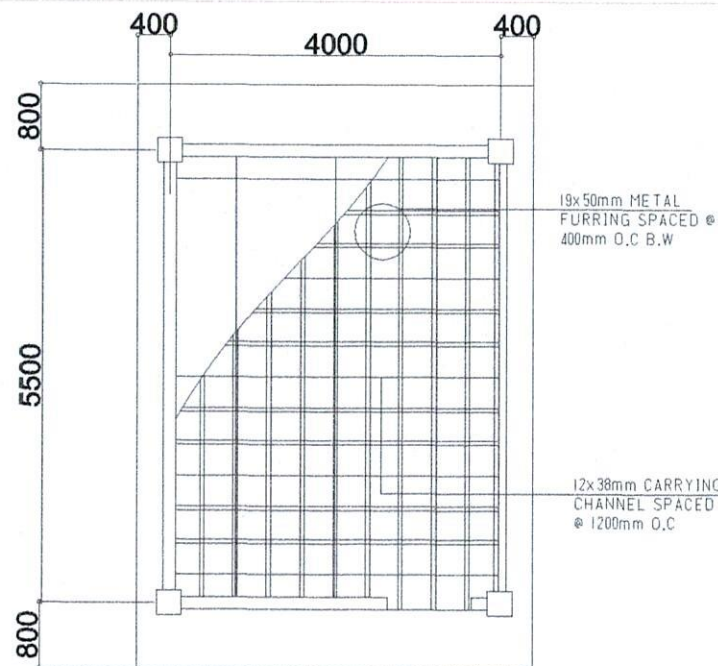


CEILING PLAN
SCALE: 1:25HTS

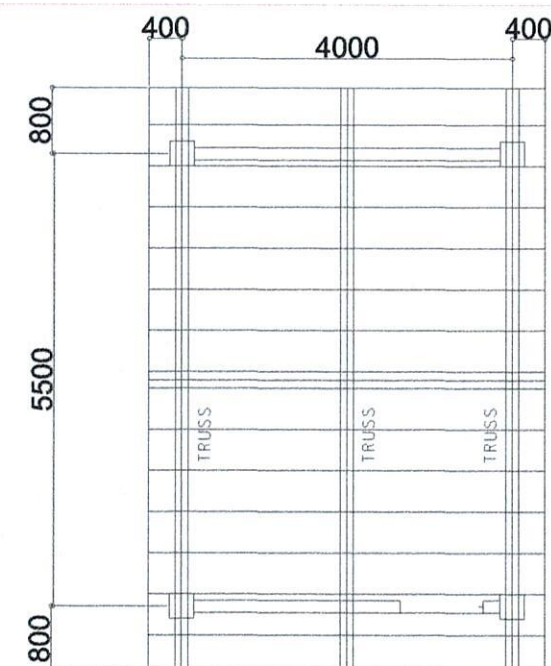

ROOF FRAMING PLAN
SCALE: 1:25HTS

PRINCIPAL OFFICE

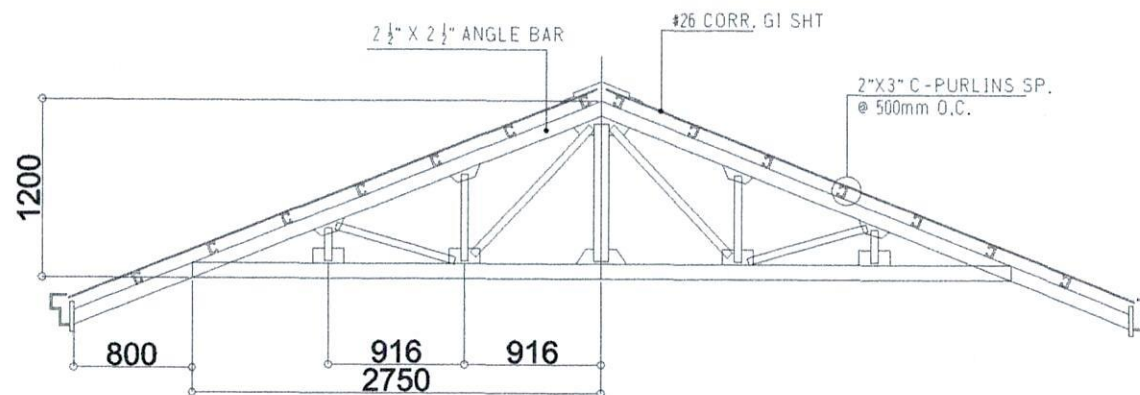


TRUSS DET.
SCALE: 1:80MTS



CITY ENGINEER'S
OFFICE

PROJECT TITLE:	DRAWN BY:	RECOMMENDING APPROVAL:	APPROVED BY:
REPAIR/IMPROV. OF MULTI-PURPOSE HALL (TUGOS ELEMENTARY SCHOOL)			
LOC: BRGY. TUGOS, WEST DISTRICT	MaPamela Legaspi	ROEL D. DOMER, C.E./RMP	MAJESTER E. HAMOR
SORSOGON CITY	DRAFTING AIDE	CITY ENGINEER	CITY MAYOR

PRINCIPAL OFFICE

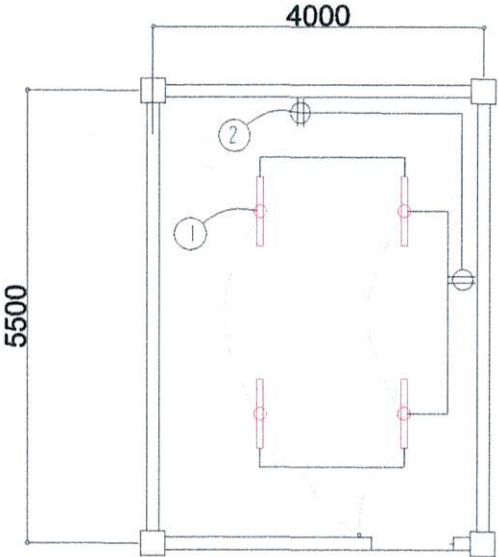

ELECTRICAL PLAN
SCALE: 1:25M

SCHEDULE OF LOADS							
CIRCUIT NO.	DESCRIPTION	NO. OF LOADS	VOLTS	WATTS	AMP	SIZE OF WIRE	SIZE OF CONDUIT
1	LIGHTING OUTLET	6	230	600	2.60	2-2.0mm² THW	15mmØ
2	CONVENIENCE OUTLET	2	230	360	1.56	2-3.5mm² THW	20mmØ
TOTAL					4.16		

ELECTRICAL NOTES

ALL ELECTRICAL WORKS SHALL BE DONE IN ACCORDANCE WITH THE LATEST RULES AND REGULATIONS OF THE PHIL. ELECTRICAL CODE AS WELL AS THE LOCAL AUTHORITY CONCERNED AND THE LOCAL POWER COMPANY.

ALL ELECTRICAL MATERIALS TO BE USED SHALL BE NEED & APPROVED TYPE FOR LOCATION & PURPOSE

- MOUNTING HEIGHTS SHALL BE AS FOLLOWS:
- a. LIGHT CONTROL SWITCH- 1.35M ABOVE FIN. FLR. LINE AT CENTER
 - b. CONVENIENCE OUTLET-ABOVE 1.0M ABOVE FIN. FLR. LINE AT CENTER
 - c. PANEL BOARD- 2.0 M ABOVE FIN. FLR. LINE




ALL ELECTRICAL WORKS SHALL BE UNDER THE DIRECT & IMMEDIATE SUPERVISION OF A DULY LICENSED ELECTRICAL ENGINEER OR REGISTERED MASTER ELECTRICIAN



CITY ENGINEER'S
O F F I C E

PROJECT TITLE:	DRAWN BY:	RECOMMENDING APPROVAL :	APPROVED BY:
REPAIR/IMPROV. OF MULTI-PURPOSE HALL (TUGOS ELEMENTARY SCHOOL)			
LOC: BRGY. TUGOS, WEST DISTRICT	Ma Pamela Legaspi	ROEL D. DOMER, C.E./RMP	MA. ESTER E. HAMOR
SORSOGON CITY	DRAFTING AIDE	CITY ENGINEER	CITY MAYOR


BLDG. 4 - BEFF

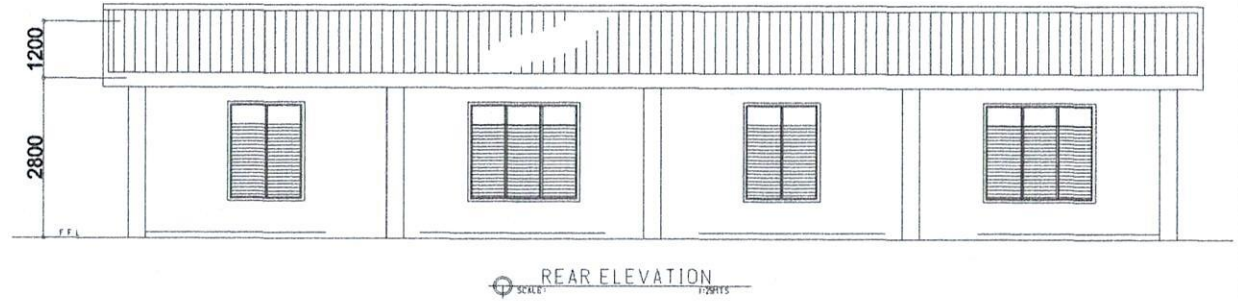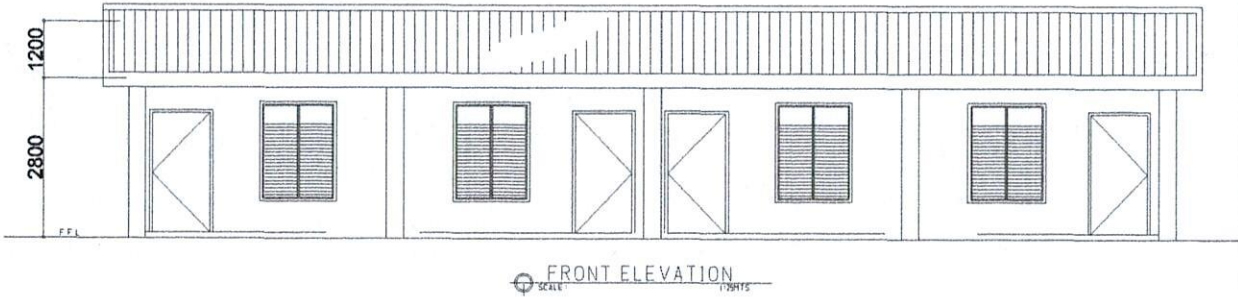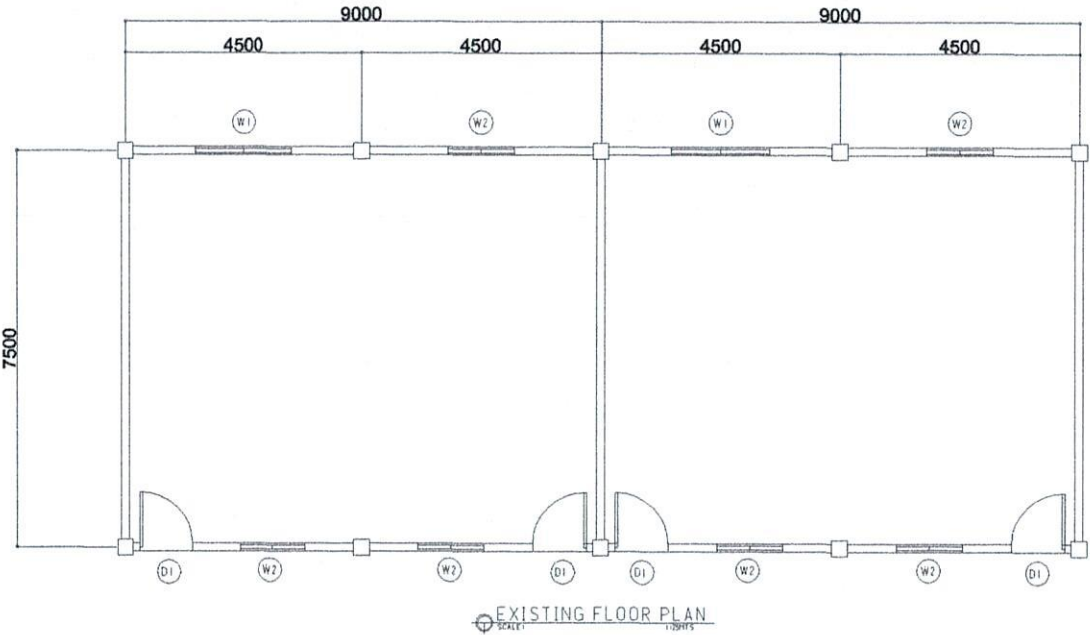


CITY ENGINEER'S
O F F I C E

PROJECT TITLE:	DRAWN BY:	RECOMMENDING APPROVAL :	APPROVED BY:
REPAIR/IMPROV. OF MULTI-PURPOSE HALL (SAN PASCUAL ELEMENTARY SCHOOL)			
LOC: BRGY. SAN PASCUAL, BACON DISTRICT	Ma Pamela Legaspi	ROEL D. DOMER, C.E./RMP	MA. ESTER E. HAMOR
SORSOGON CITY	DRAFTING AIDE	CITY ENGINEER	CITY MAYOR


BLDG. 4 -BEFF

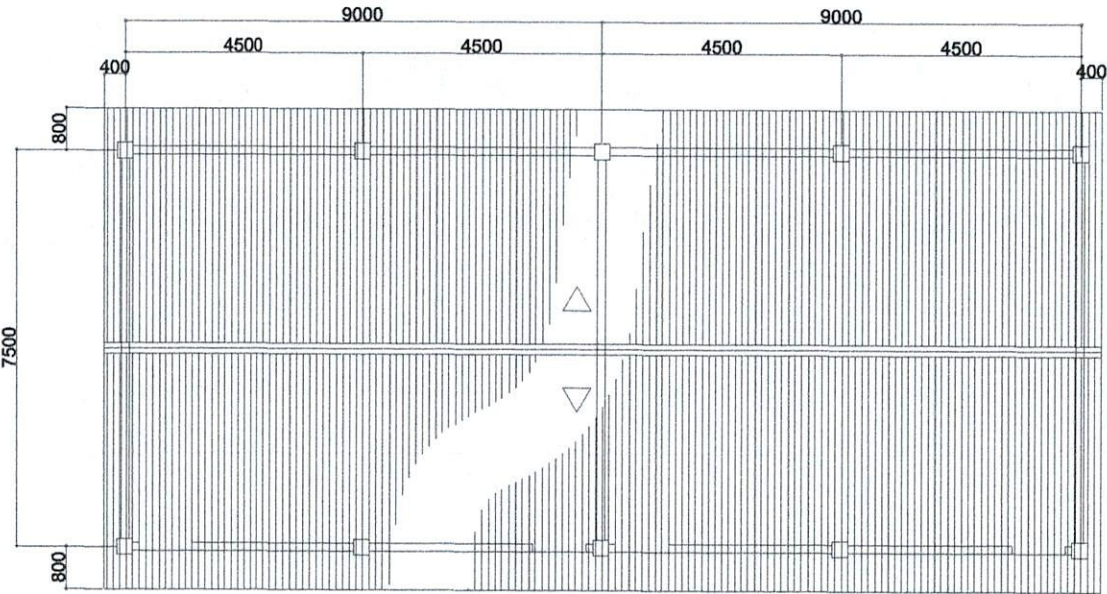


ROOF PLAN
SCALE: 1/8\"/>

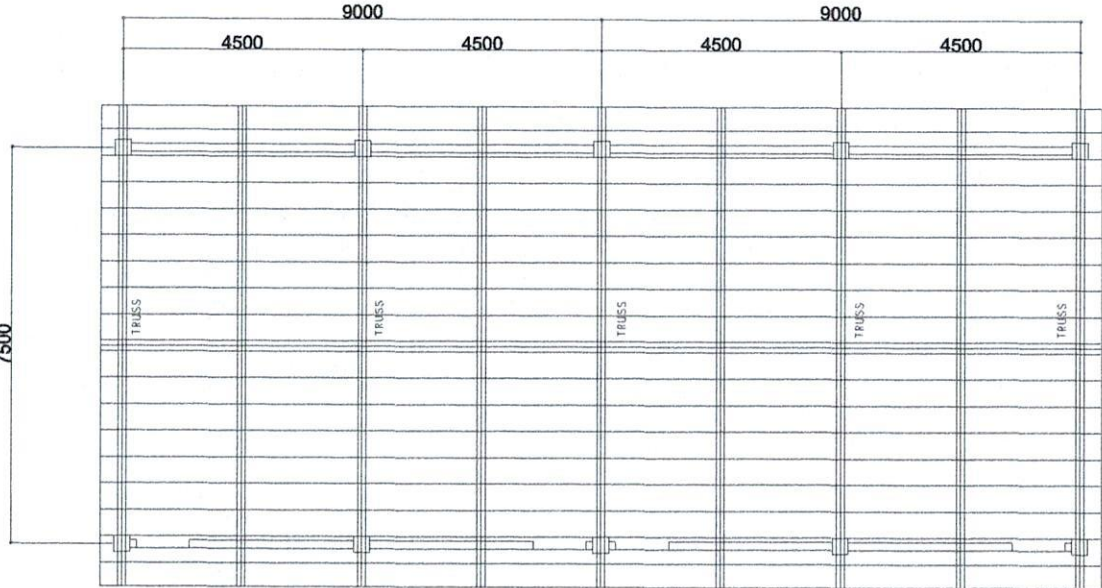

ROOF FRAMING PLAN
SCALE: 1/8\"/>

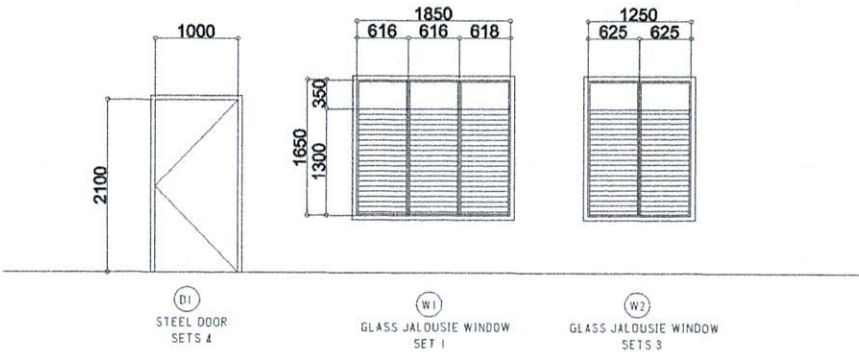

DOORS & WINDOWS SCHEDULE
SCALE: 1/8\"/>

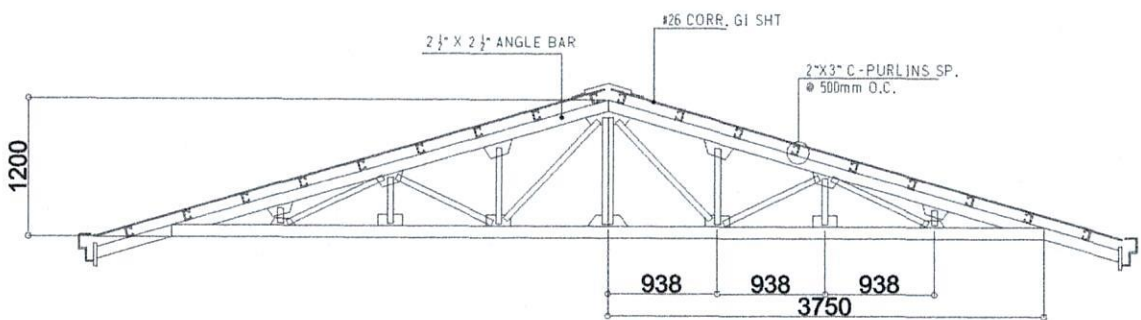



TRUSS DET.
SCALE: 1/8\"/>



CITY ENGINEER'S
O F F I C E

PROJECT TITLE:	DRAWN BY:	RECOMMENDING APPROVAL :	APPROVED BY:
REPAIR/IMPROV. OF MULTI-PURPOSE HALL (SAN PASCUAL ELEMENTARY SCHOOL)	Ma Pamela Legaspi	ROEL D. DOMER, C.E./RMP	MA. ESTER E. HAMOR
LOC: BRGY. SAN PASCUAL, BACON DISTRICT	DRAFTING AIDE	CITY ENGINEER	CITY MAYOR
SORSOGON CITY			

BLDG. 4 -BEFF

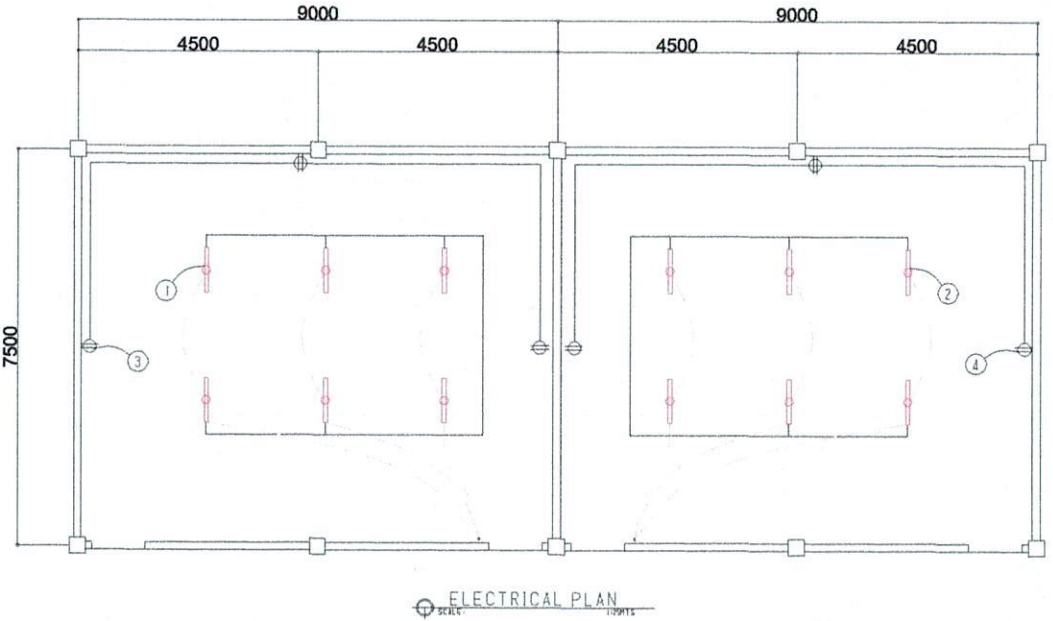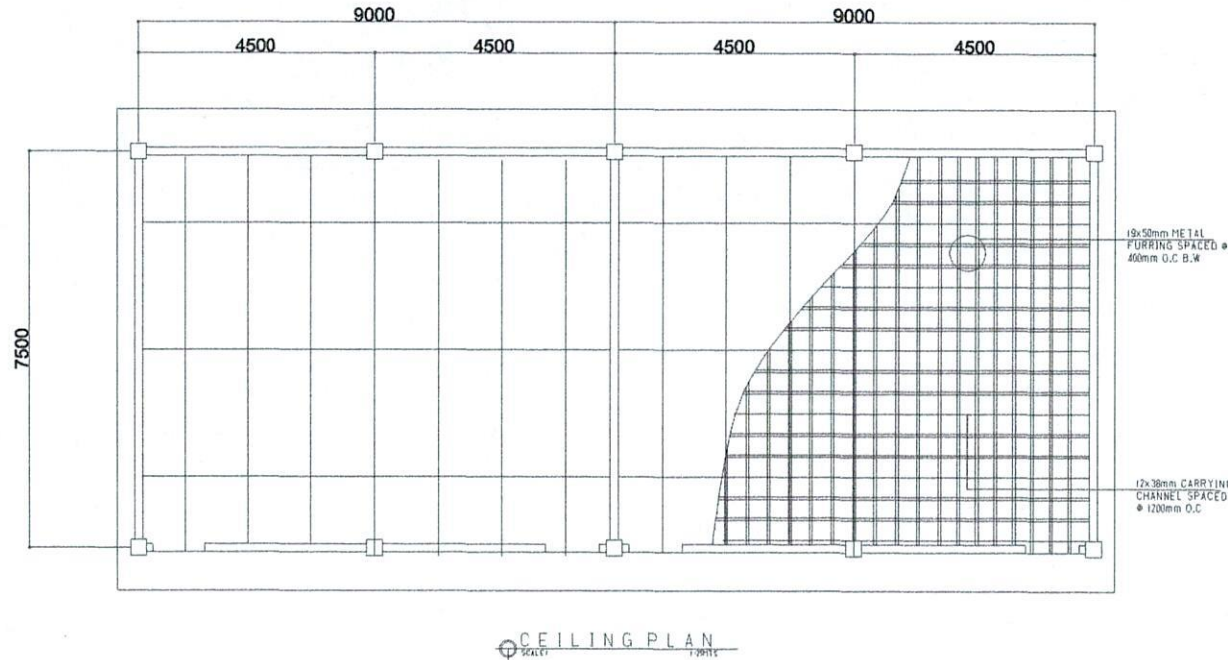

SCHEDULE OF LOADS							
CIRCUIT NO.	DESCRIPTION	NO. OF LOADS	VOLTS	WATTS	AMP	SIZE OF WIRE	SIZE OF CONDUIT
1	LIGHTING OUTLET	6	230	600	2.60	2-2.0mm ² THW	15mmØ
2	LIGHTING OUTLET	6	230	600	2.60	2-2.0mm ² THW	15mmØ
3	CONVENIENCE OUTLET	3	230	540	2.34	2-3.5mm ² THW	20mmØ
4	CONVENIENCE OUTLET	3	230	540	2.34	2-3.5mm ² THW	20mmØ
TOTAL					9.88		

ELECTRICAL NOTES

ALL ELECTRICAL WORKS SHALL BE DONE IN ACCORDANCE WITH THE LATEST RULES AND REGULATIONS OF THE PHIL. ELECTRICAL CODE AS WELL AS THE LOCAL AUTHORITY CONCERNED AND THE LOCAL POWER COMPANY.

ALL ELECTRICAL MATERIALS TO BE USED SHALL BE NEED & APPROVED TYPE FOR LOCATION & PURPOSE

MOUNTING HEIGHTS SHALL BE AS FOLLOWS:

- a. LIGHT CONTROL SWITCH- 1.35M ABOVE FIN. FLR. LINE AT CENTER
- b. CONVENIENCE OUTLET-ABOVE 1.0M ABOVE FIN. FLR. LINE AT CENTER
- c. PANEL BOARD- 2.0 M ABOVE FIN. FLR. LINE




ALL ELECTRICAL WORKS SHALL BE UNDER THE DIRECT & IMMEDIATE SUPERVISION OF A DULY LICENSED ELECTRICAL ENGINEER OR REGISTERED MASTER ELECTRICIAN



CITY ENGINEER'S
O F F I C E

PROJECT TITLE:	DRAWN BY:	RECOMMENDING APPROVAL :	APPROVED BY:
REPAIR/IMPROV. OF MULTI-PURPOSE HALL (SAN PASCUAL ELEMENTARY SCHOOL)			
LOC: BRGY. SAN PASCUAL, BACON DISTRICT	MaPamela Legaspi	ROEL D. DOMER, C.E./RMP	MA. ESTER E. HAMOR
SORSOGON CITY	DRAFTING AIDE	CITY ENGINEER	CITY MAYOR


BLDG. 2

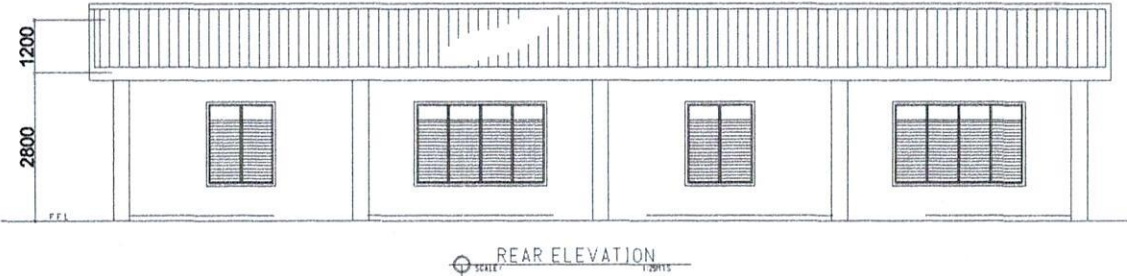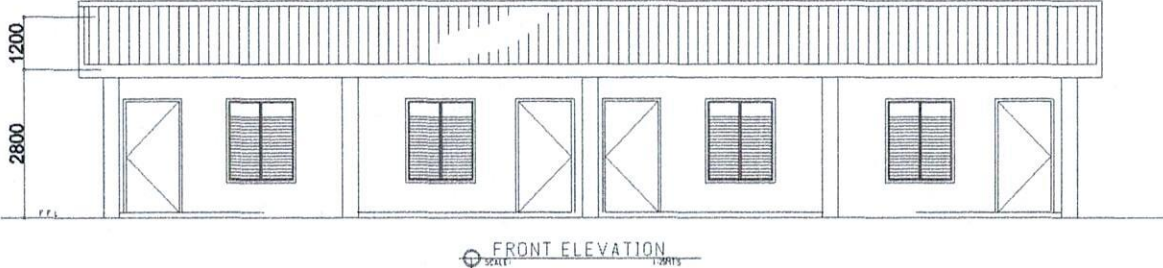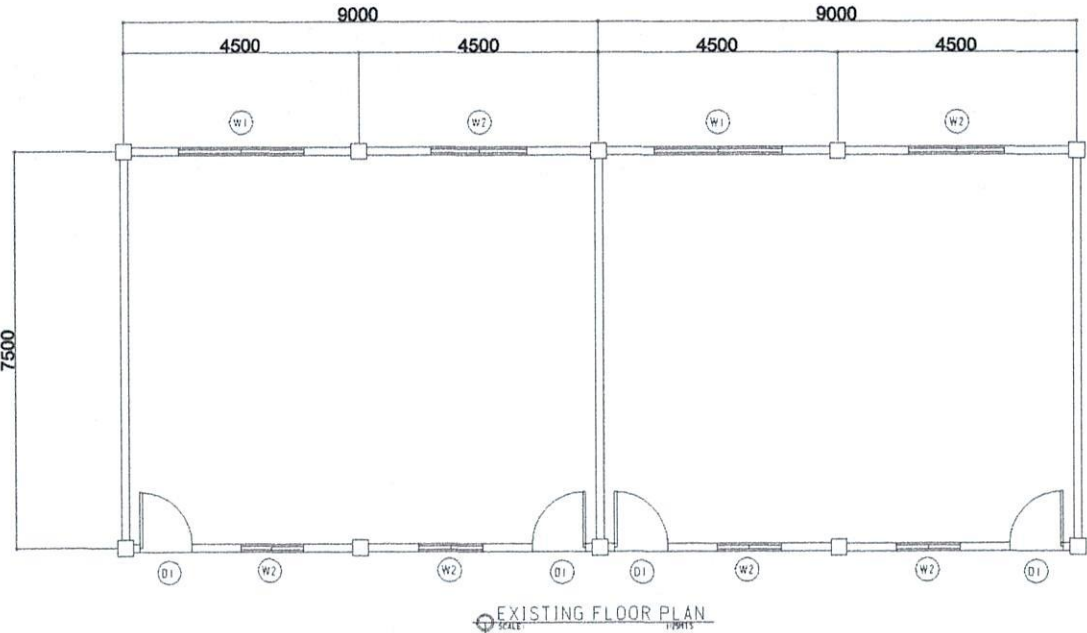


CITY ENGINEER'S
O F F I C E

PROJECT TITLE:	DRAWN BY:	RECOMMENDING APPROVAL :	APPROVED BY:
REPAIR/IMPROV. OF MULTI-PURPOSE HALL (SAN PASCUAL ELEMENTARY SCHOOL)			
LOC: BRGY. SAN PASCUAL, BACON DISTRICT	MaPamelaLegaspi	ROEL D. DOMER, C.E./RMP	MA. ESTER E. HAMOR
SORSOGON CITY	DRAFTING AIDE	CITY ENGINEER	CITY MAYOR


BLDG. 2

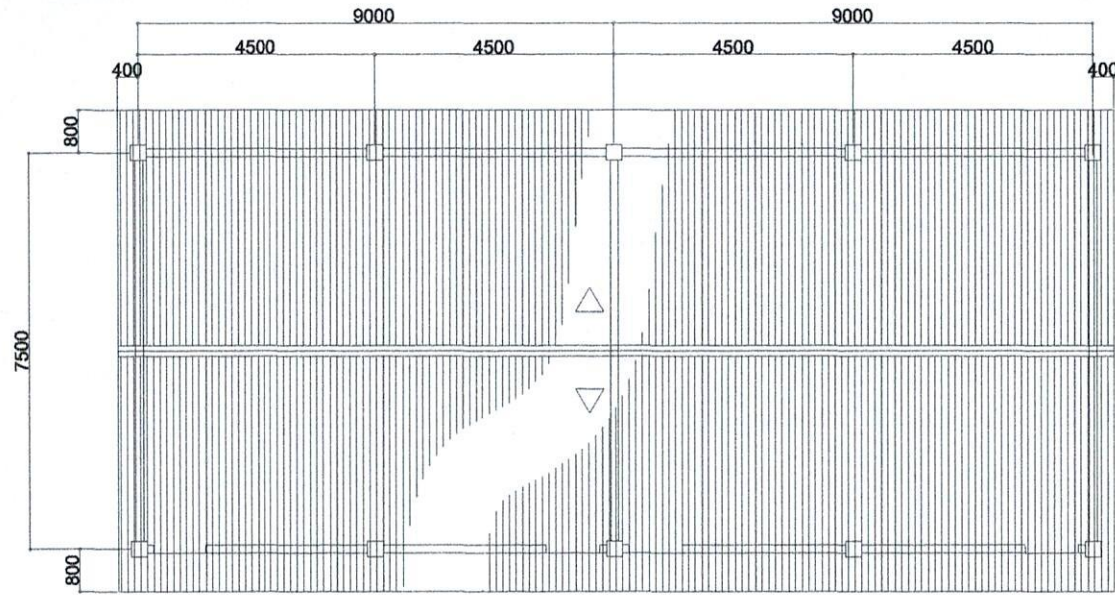

ROOF PLAN
SCALE: 1:250

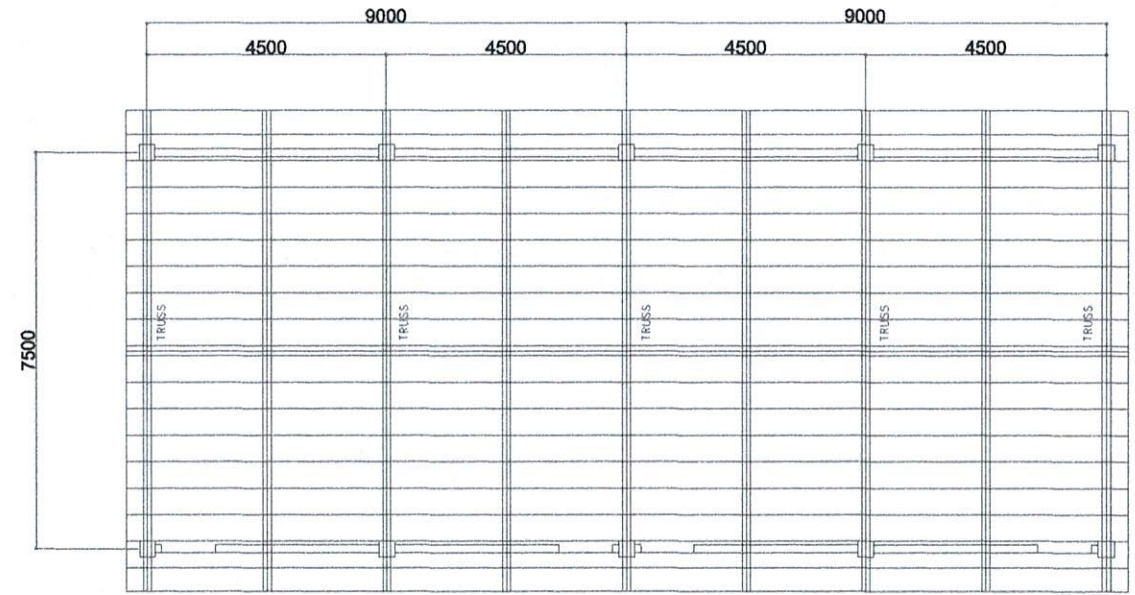

ROOF FRAMING PLAN
SCALE: 1:250

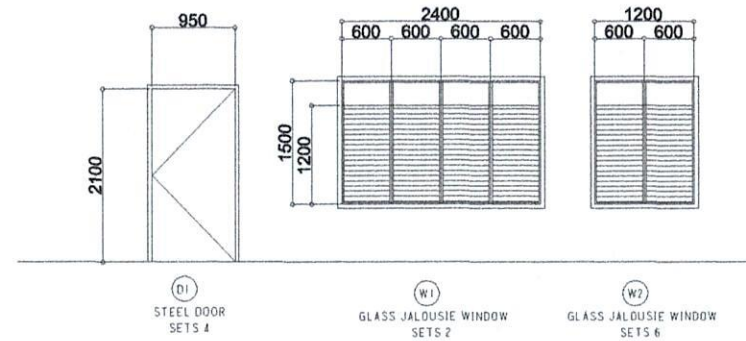



DOORS & WINDOWS SCHEDULE
SCALE: 1:250



CITY ENGINEER'S
O F F I C E

PROJECT TITLE:	DRAWN BY:	RECOMMENDING APPROVAL :	APPROVED BY:
REPAIR/IMPROV. OF MULTI-PURPOSE HALL (SAN PASCUAL ELEMENTARY SCHOOL)			
LOC: BRGY. SAN PASCUAL, BACON DISTRICT	MaPamelaLegaspi	ROEL D. DOMER, C.E./RMP	MA. ESTER E. HAMOR
SORSOGON CITY	DRAFTING AIDE	CITY ENGINEER	CITY MAYOR

BLDG. 2

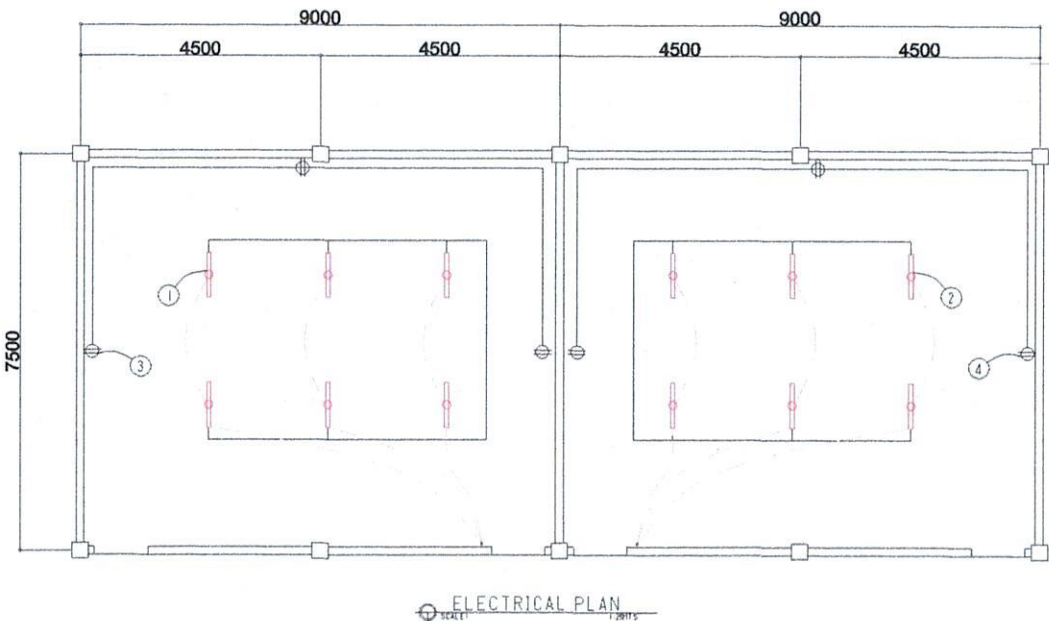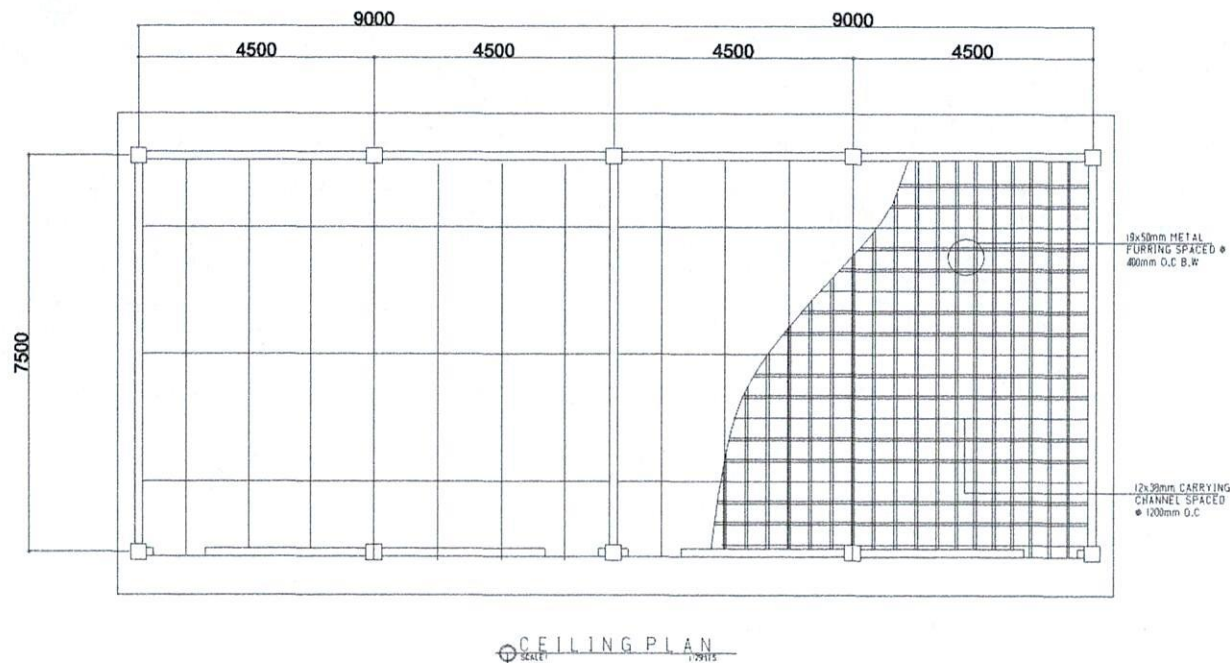

SCHEDULE OF LOADS							
CIRCUIT NO.	DESCRIPTION	NO. OF LOADS	VOLTS	WATTS	AMP	SIZE OF WIRE	SIZE OF CONDUIT
1	LIGHTING OUTLET	6	230	600	2.60	2-2.0mm ² THW	15mmØ
2	LIGHTING OUTLET	6	230	600	2.60	2-2.0mm ² THW	15mmØ
3	CONVENIENCE OUTLET	3	230	540	2.34	2-3.5mm ² THW	20mmØ
4	CONVENIENCE OUTLET	3	230	540	2.34	2-3.5mm ² THW	20mmØ
TOTAL					9.88		

ELECTRICAL NOTES

ALL ELECTRICAL WORKS SHALL BE DONE IN ACCORDANCE WITH THE LATEST RULES AND REGULATIONS OF THE PHIL. ELECTRICAL CODE AS WELL AS THE LOCAL AUTHORITY CONCERNED AND THE LOCAL POWER COMPANY.

ALL ELECTRICAL MATERIALS TO BE USED SHALL BE NEED & APPROVED TYPE FOR LOCATION & PURPOSE

MOUNTING HEIGHTS SHALL BE AS FOLLOWS:

- a. LIGHT CONTROL SWITCH- 1.35M ABOVE FIN. FLR. LINE AT CENTER
- b. CONVENIENCE OUTLET-ABOVE 1.0M ABOVE FIN. FLR. LINE AT CENTER
- c. PANEL BOARD- 2.0 M ABOVE FIN. FLR. LINE


ALL ELECTRICAL WORKS SHALL BE UNDER THE DIRECT & IMMEDIATE SUPERVISION OF A DULY LICENSED ELECTRICAL ENGINEER OR REGISTERED MASTER ELECTRICIAN




CITY ENGINEER'S
O F F I C E

PROJECT TITLE:	DRAWN BY:	RECOMMENDING APPROVAL :	APPROVED BY:
REPAIR/IMPROV. OF MULTI-PURPOSE HALL (SAN PASCUAL ELEMENTARY SCHOOL)			
LOC: BRGY. SAN PASCUAL, BACON DISTRICT	MaPamelaLegaspi	ROEL D. DOMER, C.E./RMP	MA. ESTER E. HAMOR
SORSOGON CITY	DRAFTING AIDE	CITY ENGINEER	CITY MAYOR


BLDG. 7

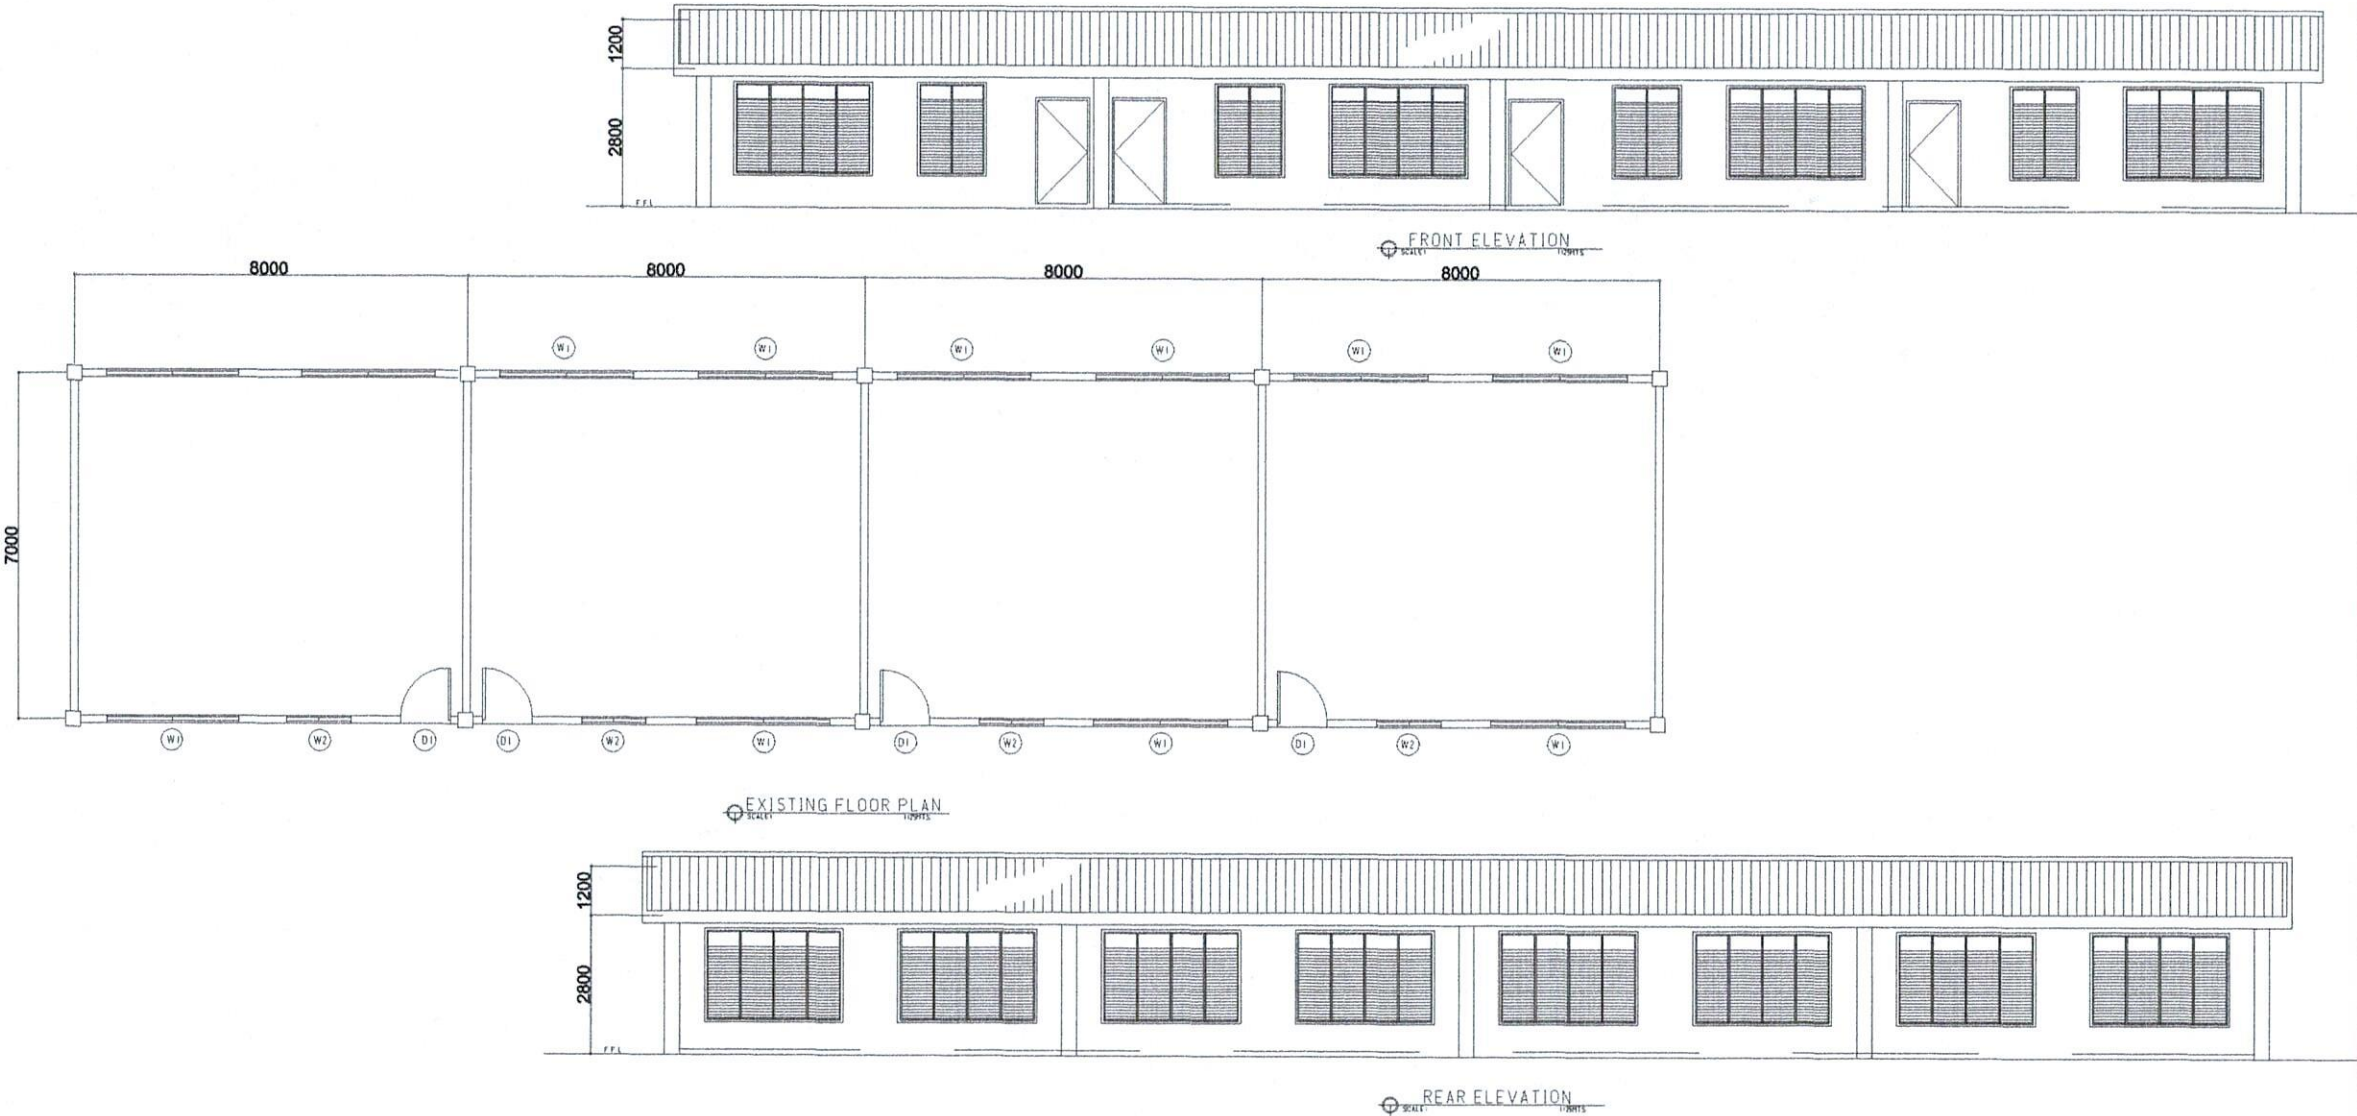


CITY ENGINEER'S
O F F I C E

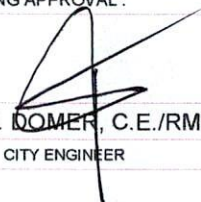PROJECT TITLE:	DRAWN BY:	RECOMMENDING APPROVAL :	APPROVED BY:
REPAIR/IMPROV. OF MULTI-PURPOSE HALL (SAN PASCUAL ELEMENTARY SCHOOL)			
LOC: BRGY. SAN PASCUAL, BACON DISTRICT	MaPamelaLegaspi	ROEL D. DOMEZ, C.E./RMP	MA. ESTER E. HAMOR
SORSOGON CITY	DRAFTING AIDE	CITY ENGINEER	CITY MAYOR


BLDG. 7

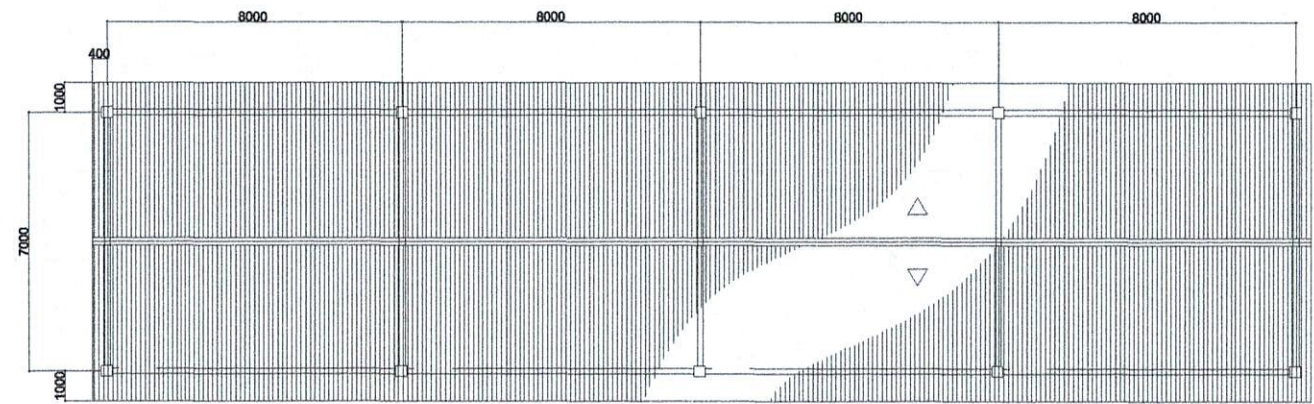

ROOF PLAN

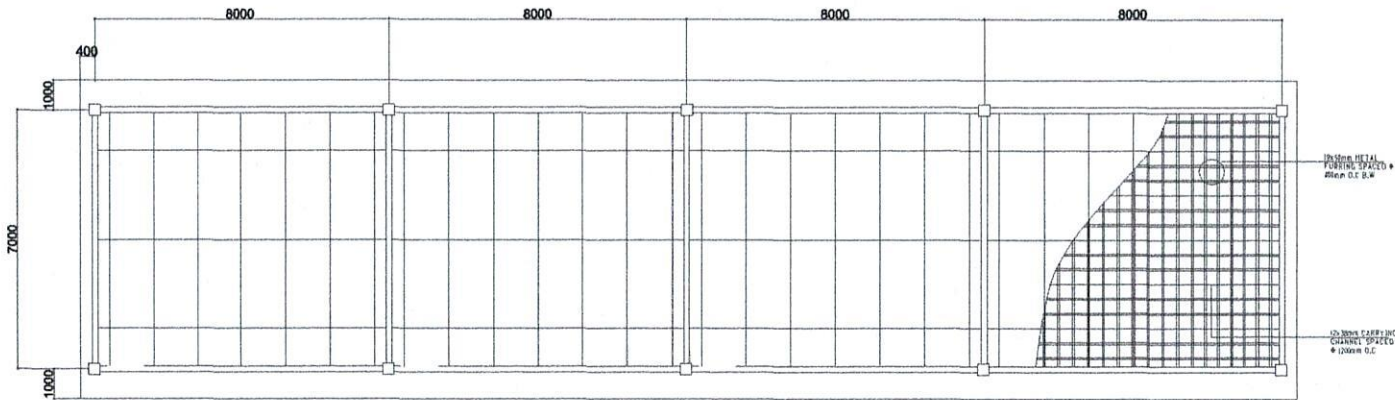

CEILING PLAN

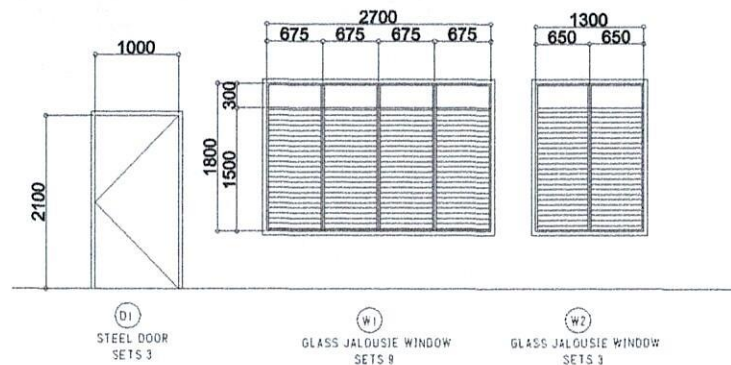

DOORS & WINDOWS SCHEDULE
SCALE: 1:250



CITY ENGINEER'S
O F F I C E

PROJECT TITLE:

REPAIR/IMPROV. OF MULTI-PURPOSE HALL
(SAN PASCUAL ELEMENTARY SCHOOL)

LOC: BRGY. SAN PASCUAL, BACON DISTRICT
SORSOGON CITY

DRAWN BY:

MaPamelaLegaspi
DRAFTING AIDE


RECOMMENDING APPROVAL :

ROEL D. DOMER, C.E./RMP
CITY ENGINEER


APPROVED BY:

MA. ESTER E. HAMOR
CITY MAYOR

BLDG. 7

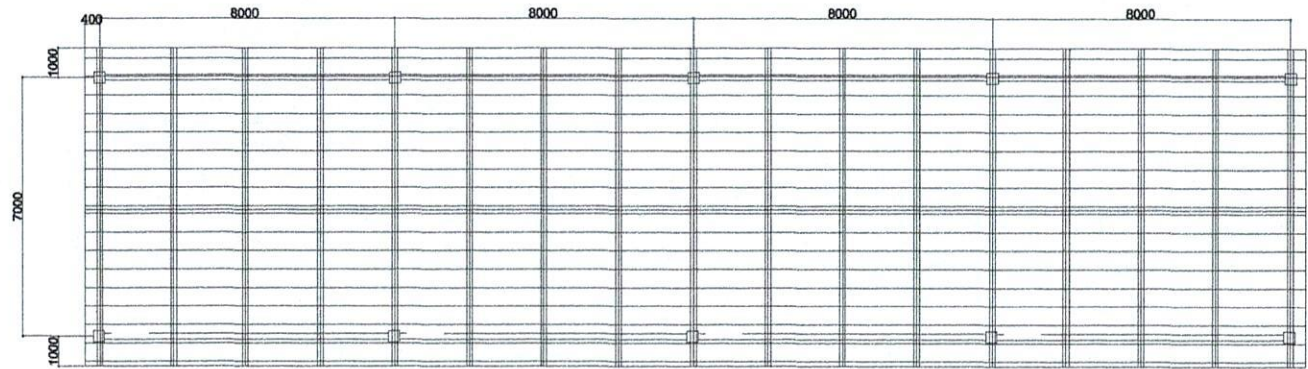

ROOF FRAMING PLAN

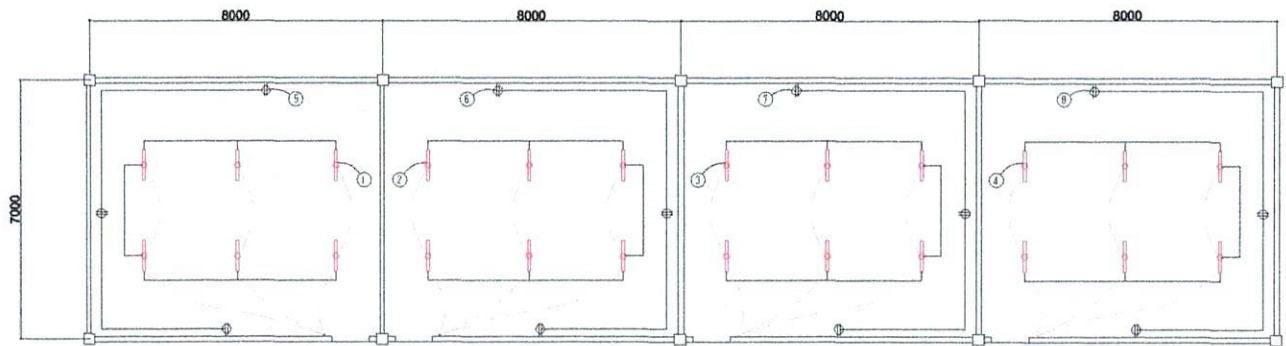

ELECTRICAL PLAN

ELECTRICAL NOTES

ALL ELECTRICAL WORKS SHALL BE DONE IN ACCORDANCE WITH THE LATEST RULES AND REGULATIONS OF THE PHIL. ELECTRICAL CODE AS WELL AS THE LOCAL AUTHORITY CONCERNED AND THE LOCAL POWER COMPANY.

ALL ELECTRICAL MATERIALS TO BE USED SHALL BE NEED & APPROVED TYPE FOR LOCATION & PURPOSE

- MOUNTING HEIGHTS SHALL BE AS FOLLOWS:
- a. LIGHT CONTROL SWITCH- 1.35M ABOVE FIN. FLR. LINE AT CENTER
 - b. CONVENIENCE OUTLET-ABOVE 1.0M ABOVE FIN. FLR. LINE AT CENTER
 - c. PANEL BOARD- 2.0 M ABOVE FIN. FLR. LINE

ALL ELECTRICAL WORKS SHALL BE UNDER THE DIRECT & IMMEDIATE SUPERVISION OF A DULY LICENSED ELECTRICAL ENGINEER OR REGISTERED MASTER ELECTRICIAN

SCHEDULE OF LOADS

CIRCUIT NO.	DESCRIPTION	NO. OF LOADS	VOLTS	WATTS	AMP	SIZE OF WIRE	SIZE OF CONDUIT
1	LIGHTING OUTLET	6	230	600	2.60	2-2.0mm ² THW	15mmØ
2	LIGHTING OUTLET	6	230	600	2.60	2-2.0mm ² THW	15mmØ
3	LIGHTING OUTLET	6	230	600	2.60	2-2.0mm ² THW	15mmØ
4	LIGHTING OUTLET	6	230	600	2.60	2-2.0mm ² THW	15mmØ
5	CONVENIENCE OUTLET	3	230	540	2.34	2-3.5mm ² THW	20mmØ
6	CONVENIENCE OUTLET	3	230	540	2.34	2-3.5mm ² THW	20mmØ
7	CONVENIENCE OUTLET	3	230	540	2.34	2-3.5mm ² THW	20mmØ
8	CONVENIENCE OUTLET	3	230	540	2.34	2-3.5mm ² THW	20mmØ
TOTAL					19.76		



CITY ENGINEER'S
O F F I C E

PROJECT TITLE:

REPAIR/IMPROV. OF MULTI-PURPOSE HALL
(SAN PASCUAL ELEMENTARY SCHOOL)

LOC: BRGY. SAN PASCUAL, BACON DISTRICT

SORSOGON CITY

DRAWN BY:

MaPamelaLegaspi

DRAFTING AIDE

RECOMMENDING APPROVAL :

ROEL D. BOMER, C.E./RMP




CITY ENGINEER

APPROVED BY:

MA. ESTER E. HAMOR

CITY MAYOR


BLSB 1

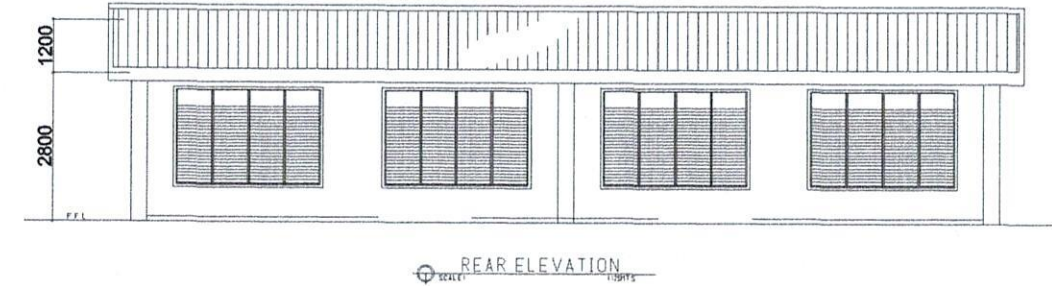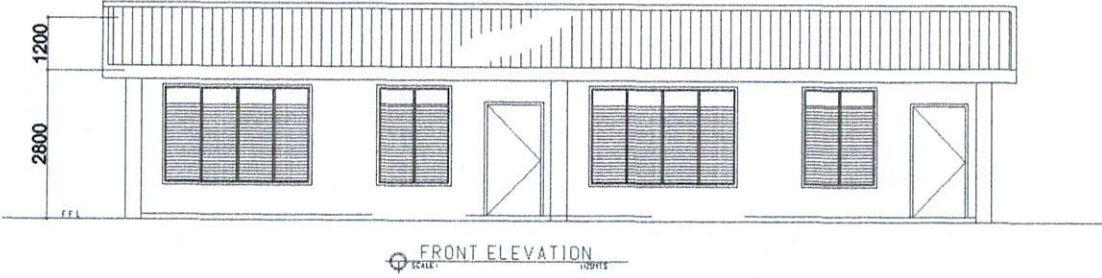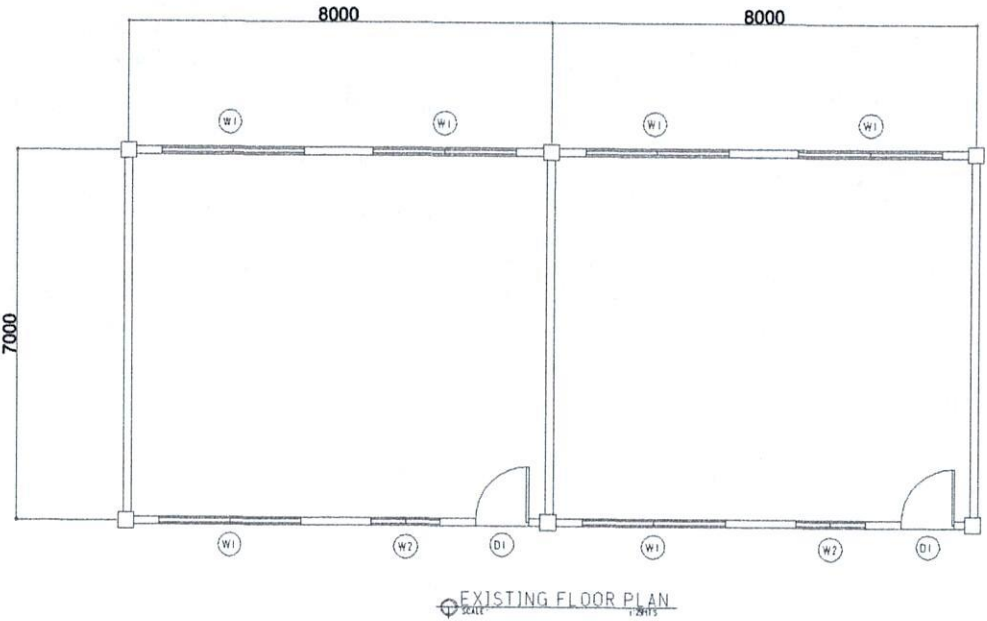


CITY ENGINEER'S
O F F I C E

PROJECT TITLE:	DRAWN BY:	RECOMMENDING APPROVAL :	APPROVED BY:
REPAIR/IMPROV. OF MULTI-PURPOSE HALL (SAN PASCUAL ELEMENTARY SCHOOL)			
LOC: BRGY. SAN PASCUAL, BACON DISTRICT SORSOGON CITY	MaPamela Legaspi DRAFTING AIDE	ROEL D. DOMER, C.E./RMP CITY ENGINEER	MA. ESTER E. HAMOR CITY MAYOR


BLSB 1

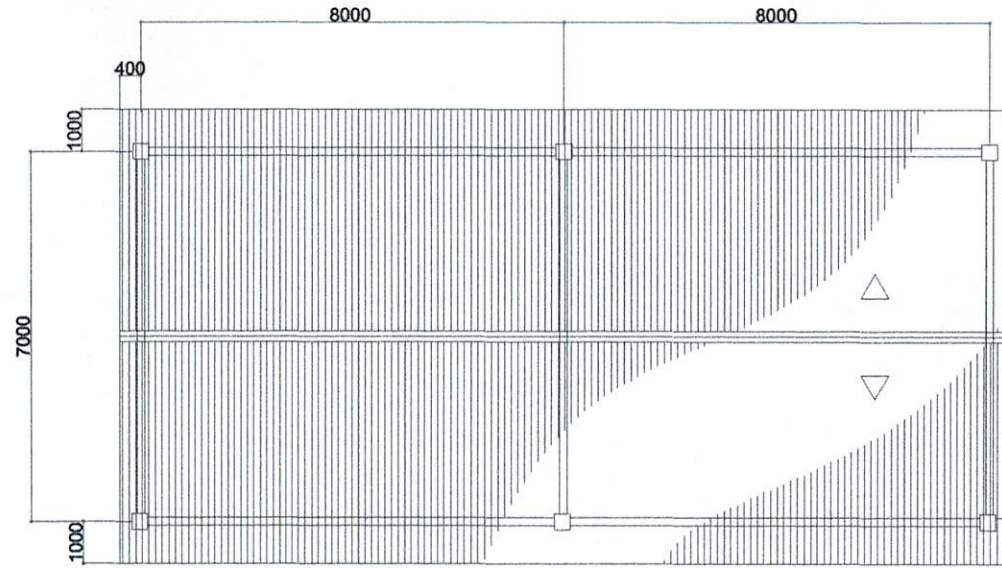

ROOF PLAN
SCALE: 1:2500

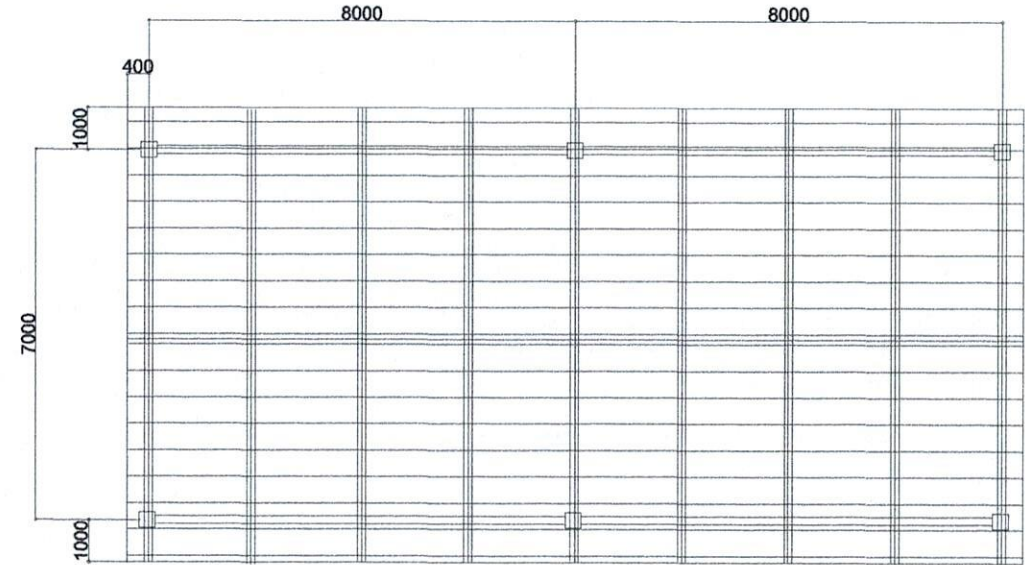

ROOF FRAMING PLAN
SCALE: 1:2500

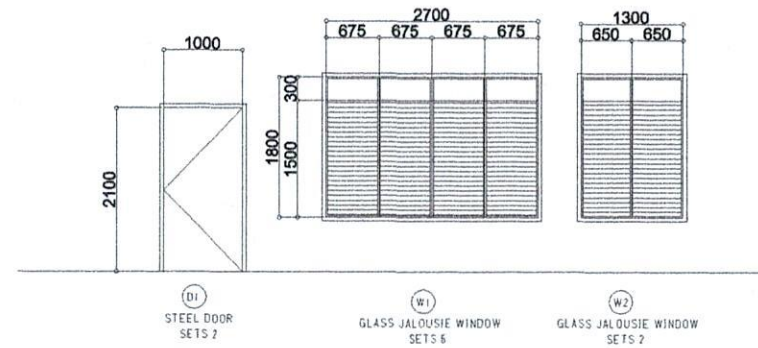


DOORS & WINDOWS SCHEDULE
SCALE: 1:2500




CITY ENGINEER'S
O F F I C E

PROJECT TITLE:	DRAWN BY:	RECOMMENDING APPROVAL:	APPROVED BY:
REPAIR/IMPROV. OF MULTI-PURPOSE HALL (SAN PASCUAL ELEMENTARY SCHOOL)			
LOC: BRGY. SAN PASCUAL, BACON DISTRICT	MaPamelaLegaspi	ROEL D. LOMER, C.E./RMP	MA. ESTER E. HAMOR
SORSOGON CITY	DRAFTING AIDE	CITY ENGINEER	CITY MAYOR

BLSB 1

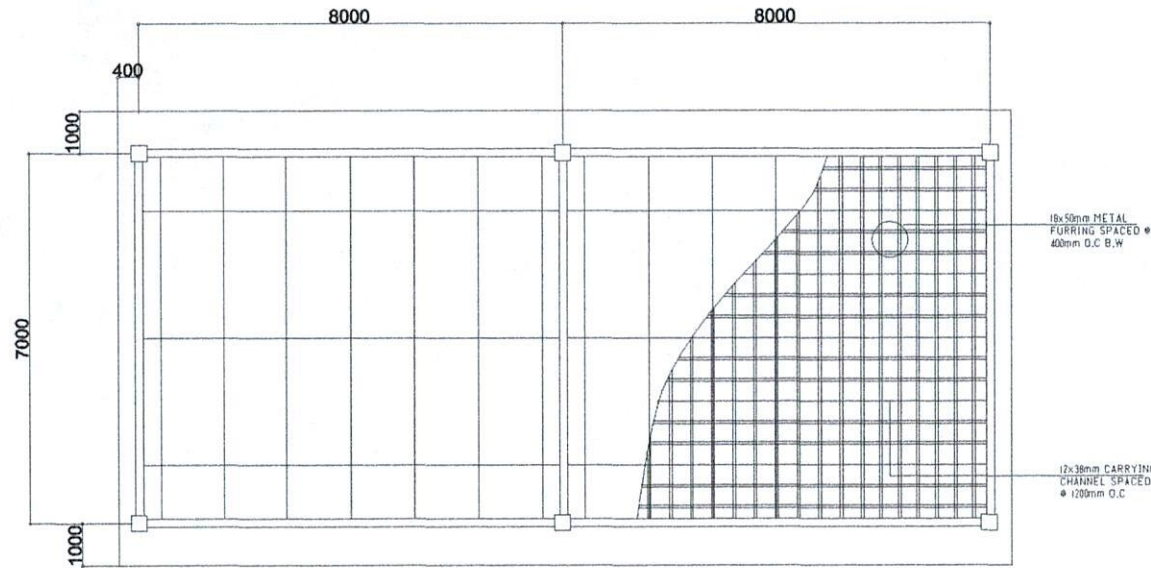

CEILING PLAN
SCALE: 1/20

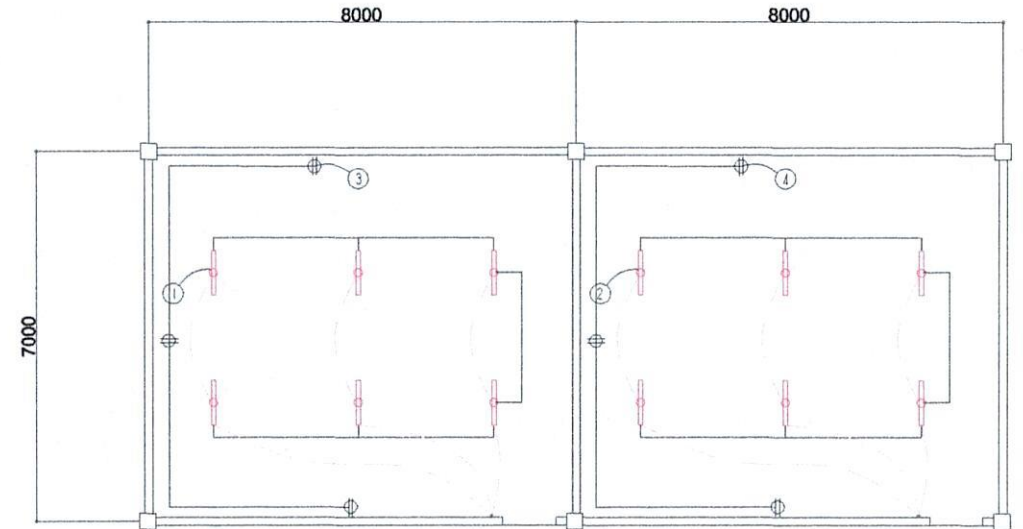

ELECTRICAL PLAN
SCALE: 1/20

SCHEDULE OF LOADS

CIRCUIT NO.	DESCRIPTION	NO. OF LOADS	VOLTS	WATTS	AMP	SIZE OF WIRE	SIZE OF CONDUIT
1	LIGHTING OUTLET	6	230	600	2.60	2-2.0mm ² THW	15mmØ
2	LIGHTING OUTLET	6	230	600	2.60	2-2.0mm ² THW	15mmØ
3	CONVENIENCE OUTLET	3	230	540	2.34	2-3.5mm ² THW	20mmØ
4	CONVENIENCE OUTLET	3	230	540	2.34	2-3.5mm ² THW	20mmØ
TOTAL					9.88		

ELECTRICAL NOTES

ALL ELECTRICAL WORKS SHALL BE DONE IN ACCORDANCE WITH THE LATEST RULES AND REGULATIONS OF THE PHIL. ELECTRICAL CODE AS WELL AS THE LOCAL AUTHORITY CONCERNED AND THE LOCAL POWER COMPANY.

ALL ELECTRICAL MATERIALS TO BE USED SHALL BE NEED & APPROVED TYPE FOR LOCATION & PURPOSE

MOUNTING HEIGHTS SHALL BE AS FOLLOWS:

- LIGHT CONTROL SWITCH- 1.35M ABOVE FIN. FLR. LINE AT CENTER
- CONVENIENCE OUTLET-ABOVE 1.0M ABOVE FIN. FLR. LINE AT CENTER
- PANEL BOARD- 2.0 M ABOVE FIN. FLR. LINE

ALL ELECTRICAL WORKS SHALL BE UNDER THE DIRECT & IMMEDIATE SUPERVISION OF A DULY LICENSED ELECTRICAL ENGINEER OR REGISTERED MASTER ELECTRICIAN



CITY ENGINEER'S
O F F I C E

PROJECT TITLE:

REPAIR/IMPROV. OF MULTI-PURPOSE HALL
(SAN PASCUAL ELEMENTARY SCHOOL)

LOC: BRGY. SAN PASCUAL, BACON DISTRICT

SORSOGON CITY

DRAWN BY:

MaPamelaLegaspi

DRAFTING AIDE




RECOMMENDING APPROVAL :

ROEL D. DOMER, C.E./RMP
CITY ENGINEER

APPROVED BY:


MA. ESTER E. HAMOR
CITY MAYOR

RM. 4,5,6,7,8,9

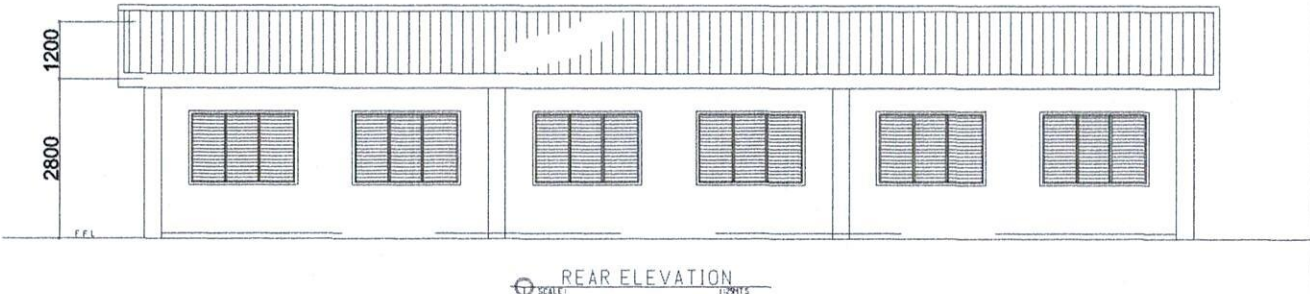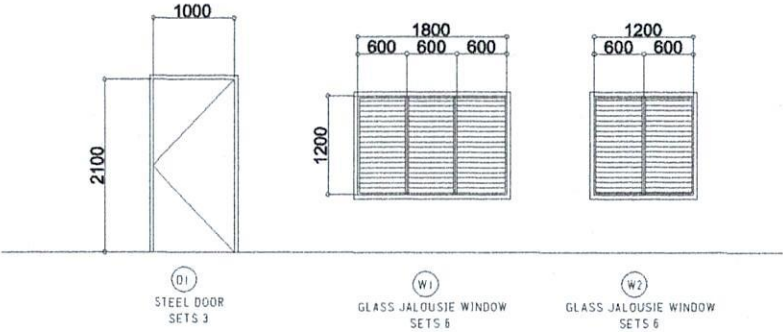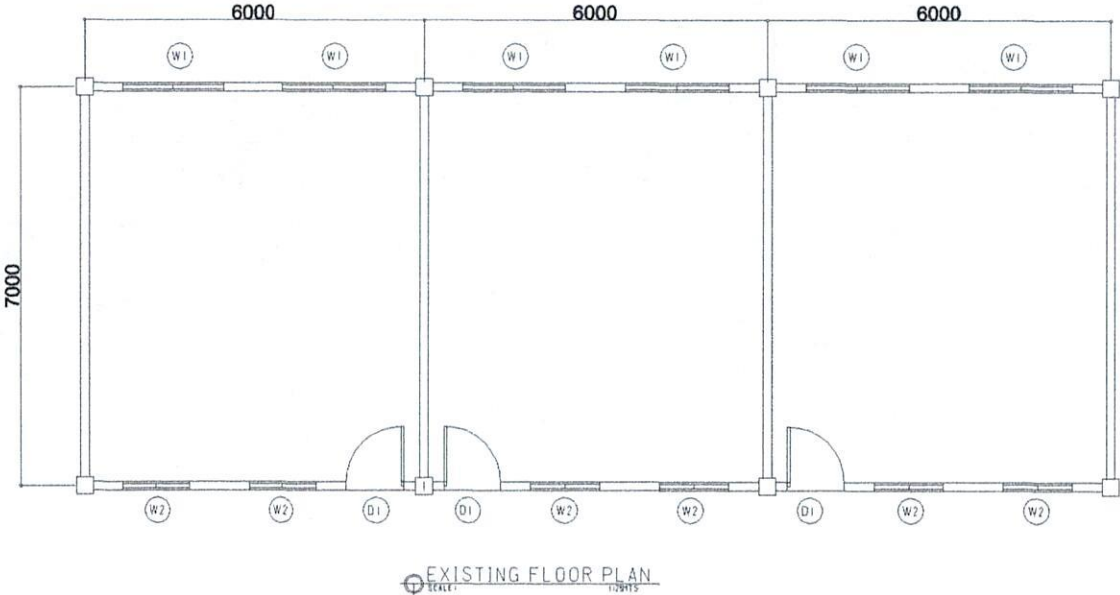


CITY ENGINEER'S
O F F I C E

PROJECT TITLE:	DRAWN BY:	RECOMMENDING APPROVAL :	APPROVED BY:
REPAIR/IMPROV. OF MULTI-PURPOSE HALL (RIZAL ELEMENTARY SCHOOL)			
LOC: BRGY. RIZAL, WEST DISTRICT	MaPamelaLegaspi	ROEL D. DOMERIO E./RMP	MA. ESTER E. HAMOR
SORSOGON CITY	DRAFTING AIDE	CITY ENGINEER	CITY MAYOR

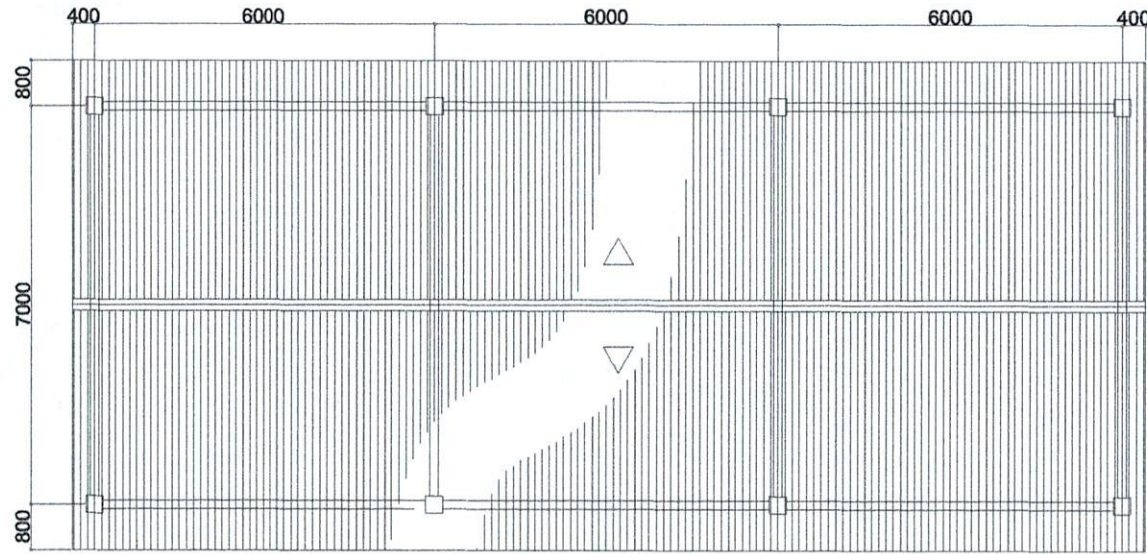


ROOF PLAN
SCALE: 1/200

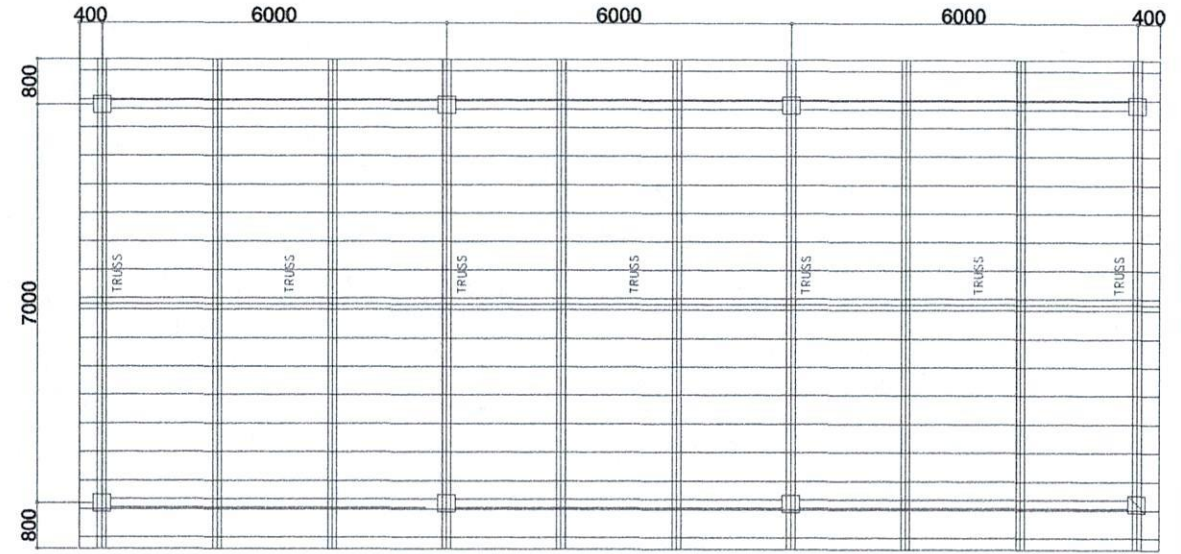

ROOF FRAMING PLAN
SCALE: 1/200

RM. 4,5,6,7,8,9

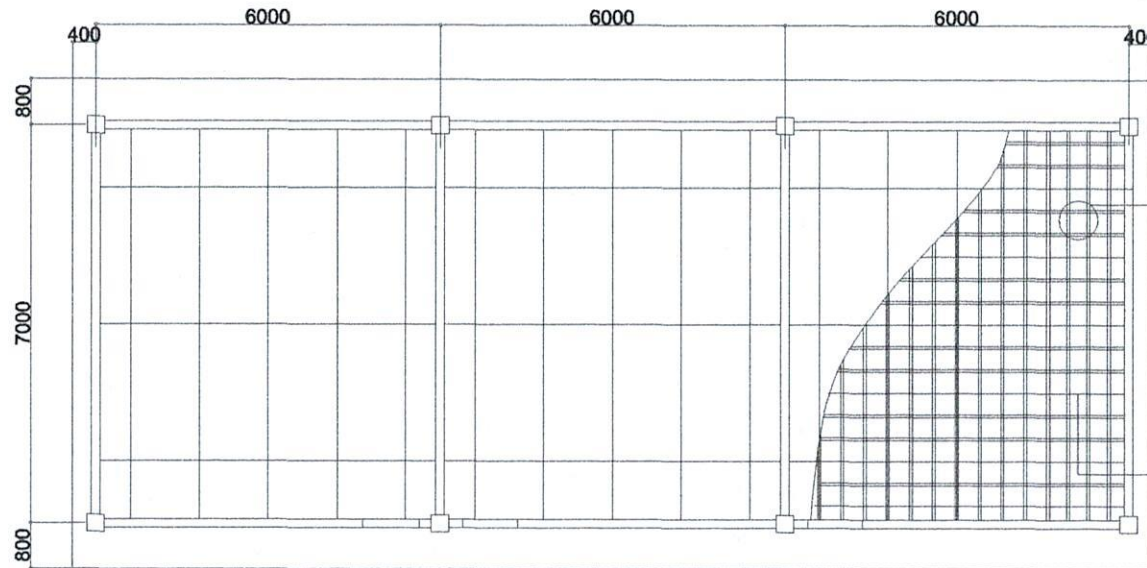

19x50mm METAL
FURRING SPACED @
400mm O.C. B.W.

12x39mm CARRYING
CHANNEL SPACED
@ 1200mm O.C.



CITY ENGINEER'S
O F F I C E

PROJECT TITLE:

REPAIR/IMPROV. OF MULTI-PURPOSE HALL
(RIZAL ELEMENTARY SCHOOL)

LOC: BRGY. RIZAL, WEST DISTRICT

SORSOGON CITY

DRAWN BY:

MaPamelaLegaspi


DRAFTING AIDE

RECOMMENDING APPROVAL :

ROEL D. DOMER, C.E./RMP
CITY ENGINEER

APPROVED BY:

MA. ESTER E. HAMOR
CITY MAYOR

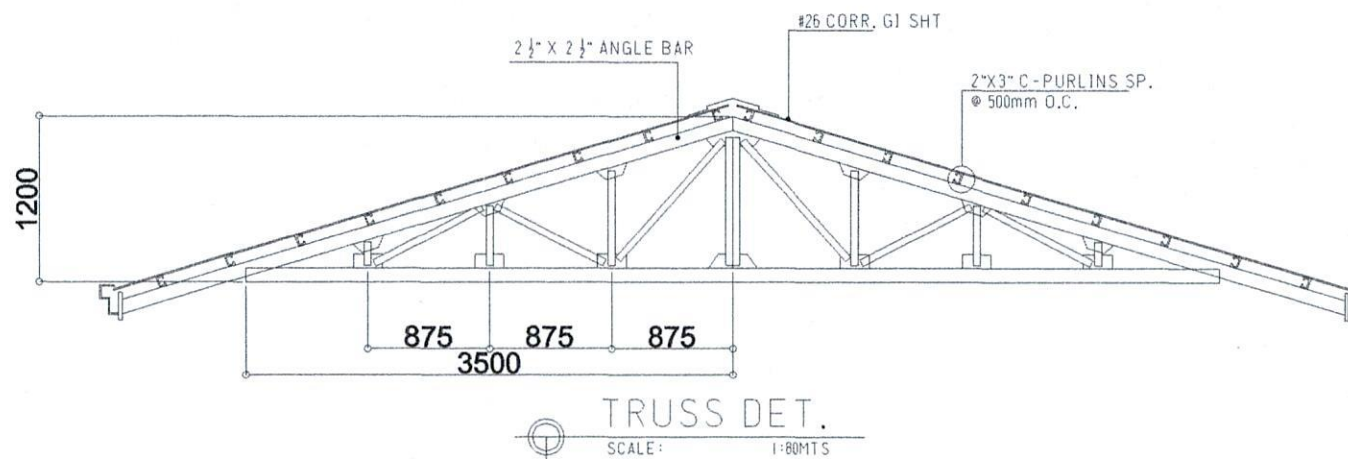

CITY ENGINEER'S
O F F I C E

PROJECT TITLE:

REPAIR/IMPROV. OF MULTI-PURPOSE HALL
(RIZAL ELEMENTARY SCHOOL)

LOC: BRGY. RIZAL, WEST DISTRICT

SORSOGON CITY

DRAWN BY:

MaPamela Legaspi

DRAFTING AIDE


RECOMMENDING APPROVAL :

ROEL D. DOMER, C.E./RMP
CITY ENGINEER

APPROVED BY:

MA. ESTER E. HAMOR
CITY MAYOR

RM. 4,5,6,7,8,9

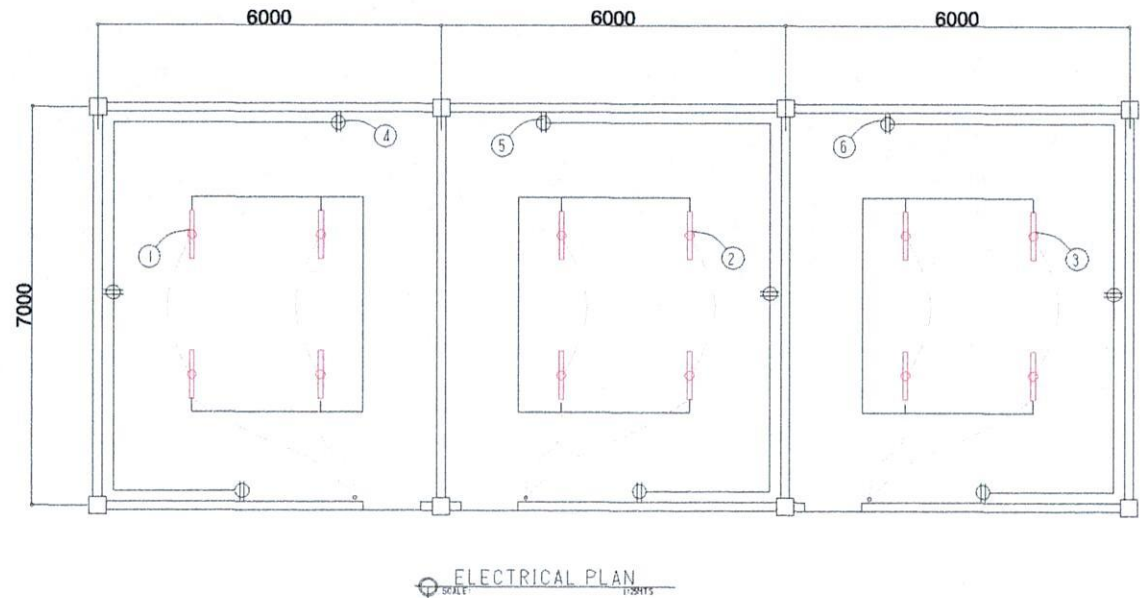

SCHEDULE OF LOADS							
CIRCUIT NO.	DESCRIPTION	NO. OF LOADS	VOLTS	WATTS	AMP	SIZE OF WIRE	SIZE OF CONDUIT
1	LIGHTING OUTLET	4	230	400	1.73	2-2.0mm ² THW	15mmØ
2	LIGHTING OUTLET	4	230	400	1.73	2-2.0mm ² THW	15mmØ
3	LIGHTING OUTLET	4	230	400	1.73	2-2.0mm ² THW	15mmØ
4	CONVENIENCE OUTLET	3	230	540	2.34	2-3.5mm ² THW	20mmØ
5	CONVENIENCE OUTLET	3	230	540	2.34	2-3.5mm ² THW	20mmØ
6	CONVENIENCE OUTLET	3	230	540	2.34	2-3.5mm ² THW	20mmØ
TOTAL					10.92		

ELECTRICAL NOTES

ALL ELECTRICAL WORKS SHALL BE DONE IN ACCORDANCE WITH THE LATEST RULES AND REGULATIONS OF THE PHIL. ELECTRICAL CODE AS WELL AS THE LOCAL AUTHORITY CONCERNED AND THE LOCAL POWER COMPANY.

ALL ELECTRICAL MATERIALS TO BE USED SHALL BE NEED & APPROVED TYPE FOR LOCATION & PURPOSE

- MOUNTING HEIGHTS SHALL BE AS FOLLOWS:
- a. LIGHT CONTROL SWITCH- 1.35M ABOVE FIN. FLR. LINE AT CENTER
 - b. CONVENIENCE OUTLET-ABOVE 1.0M ABOVE FIN. FLR. LINE AT CENTER
 - c. PANEL BOARD- 2.0 M ABOVE FIN. FLR. LINE


ALL ELECTRICAL WORKS SHALL BE UNDER THE DIRECT & IMMEDIATE SUPERVISION OF A DULY LICENSED ELECTRICAL ENGINEER OR REGISTERED MASTER ELECTRICIAN




CITY ENGINEER'S
O F F I C E

PROJECT TITLE:	DRAWN BY:	RECOMMENDING APPROVAL :	APPROVED BY:
REPAIR/IMPROV. OF MULTI-PURPOSE HALL (RIZAL ELEMENTARY SCHOOL)			
LOC: BRGY. RIZAL, WEST DISTRICT SORSOGON CITY	Ma Pamela Legaspi DRAFTING AIDE	ROEL D. DOMER, C.E./RMP CITY ENGINEER	MA. ESTER E. HAMOR CITY MAYOR


RM. 10

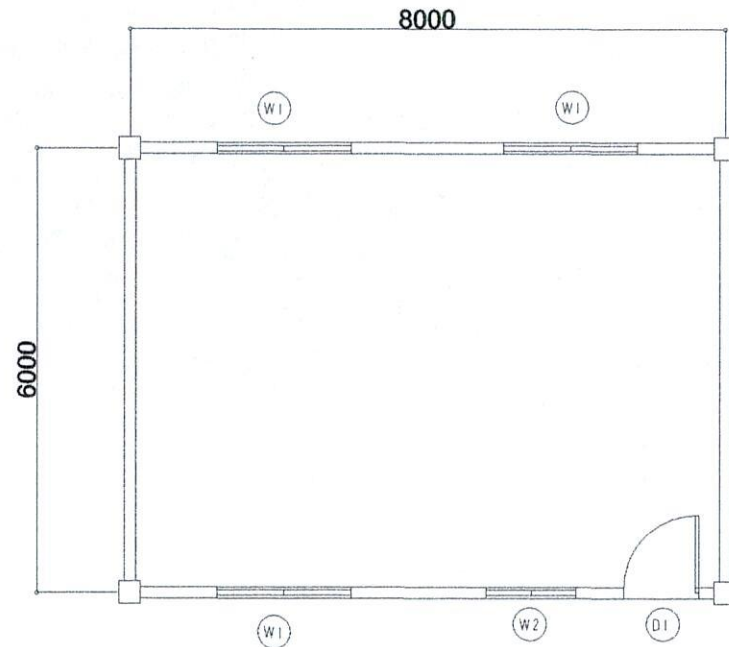


EXISTING FLOOR PLAN
SCALE: 1:25HYS

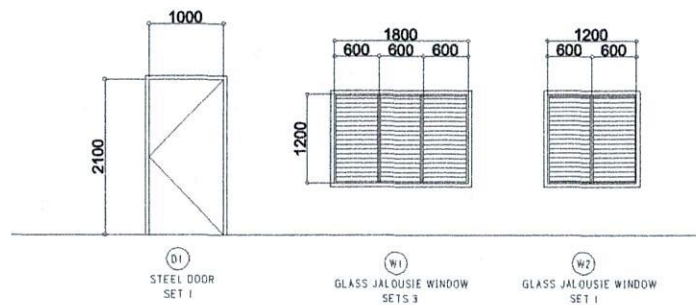

DOORS & WINDOWS SCHEDULE
SCALE: 1:25HYS

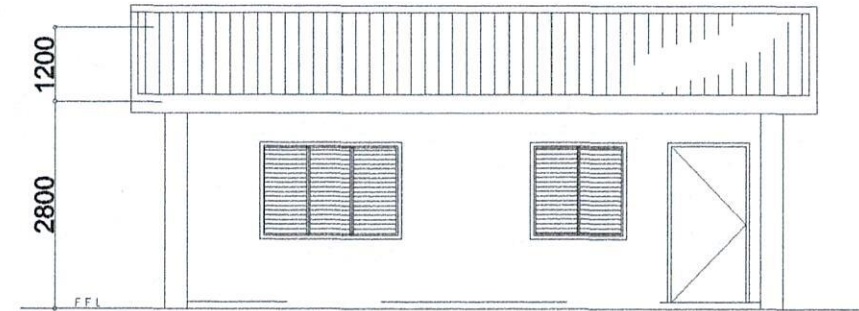

FRONT ELEVATION
SCALE: 1:25HYS

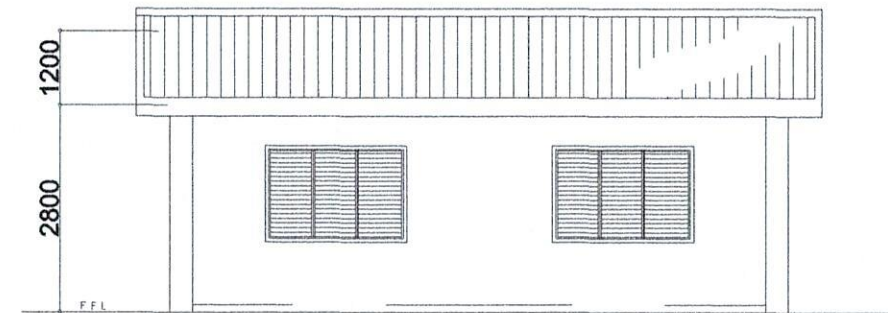


REAR ELEVATION
SCALE: 1:25HYS




CITY ENGINEER'S
OFFICE

PROJECT TITLE:	DRAWN BY:	RECOMMENDING APPROVAL :	APPROVED BY:
REPAIR/IMPROV. OF MULTI-PURPOSE HALL (RIZAL ELEMENTARY SCHOOL)			
LOC: BRGY. RIZAL, WEST DISTRICT	Ma Pamela Legaspi	ROEL D. DOMERIO, C.E./RMP	MA. ESTER E. HAMOR
SORSOGON CITY	DRAFTING AIDE	CITY ENGINEER	CITY MAYOR


RM. 10

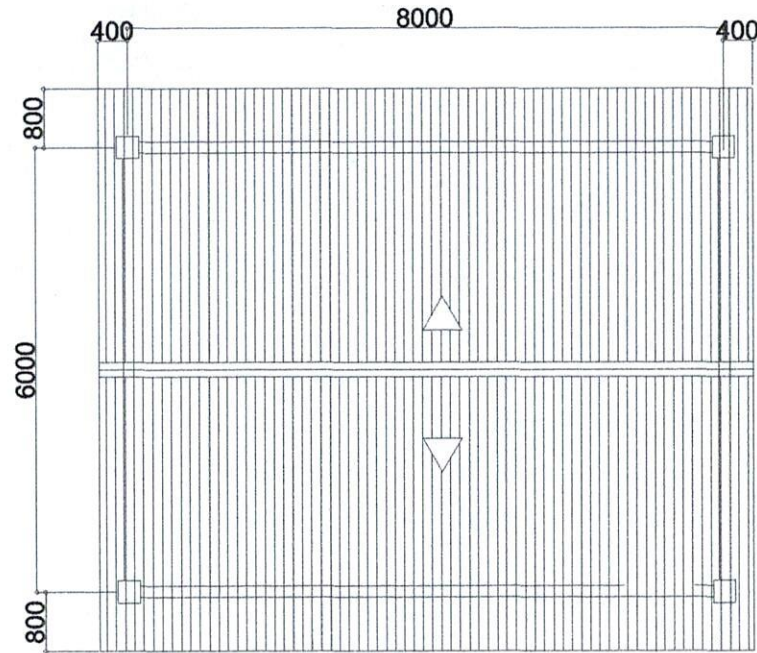

ROOF PLAN
SCALE: 1:250MTS

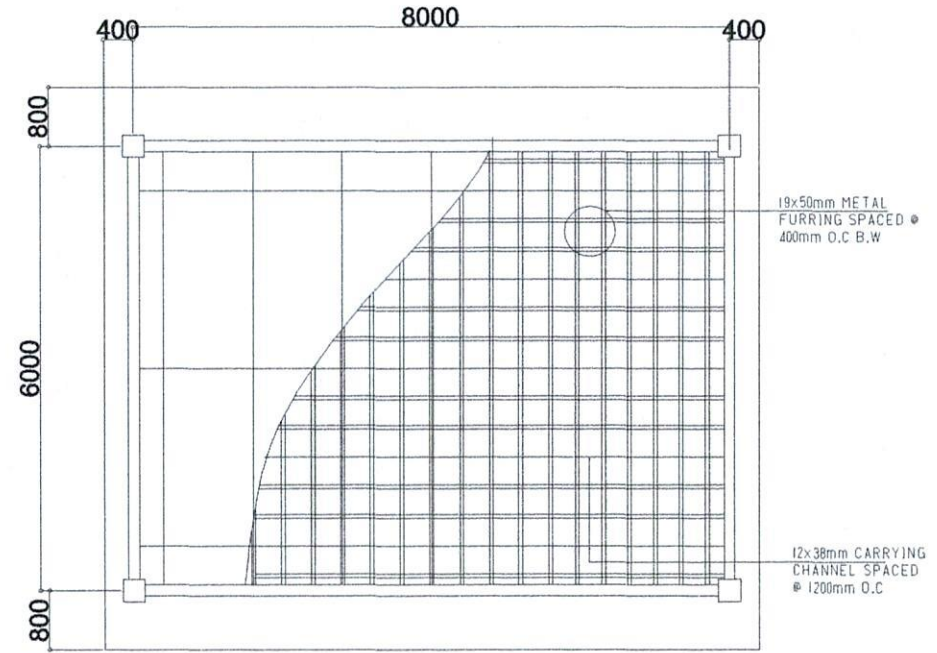

CEILING PLAN
SCALE: 1:250MTS

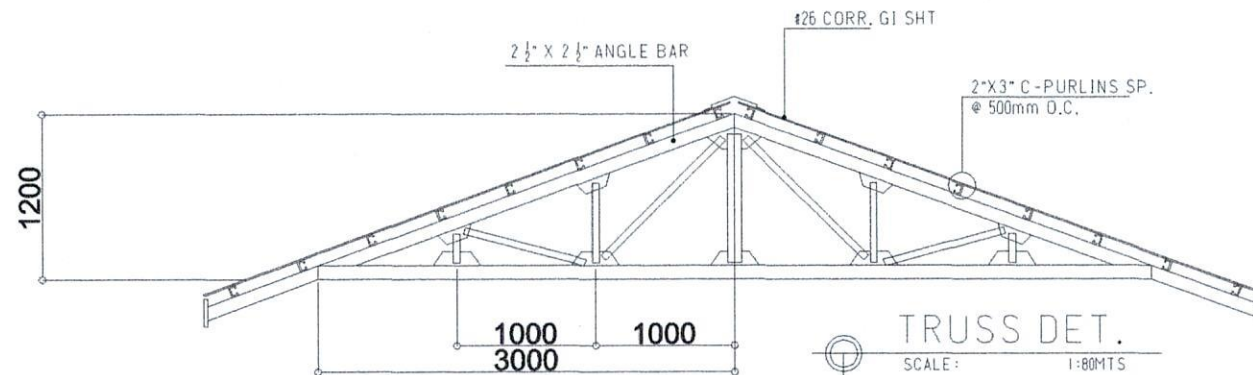

TRUSS DET.
SCALE: 1:80MTS



CITY ENGINEER'S
O F F I C E

PROJECT TITLE:

REPAIR/IMPROV. OF MULTI-PURPOSE HALL
(RIZAL ELEMENTARY SCHOOL)

LOC: BRGY. RIZAL, WEST DISTRICT
SORSOGON CITY

DRAWN BY:


MaPamela Legaspi
DRAFTING AIDE

RECOMMENDING APPROVAL :


ROEL D. DOMER, C.E./RMP
CITY ENGINEER

APPROVED BY:

MA. ESTER E. HAMOR
CITY MAYOR

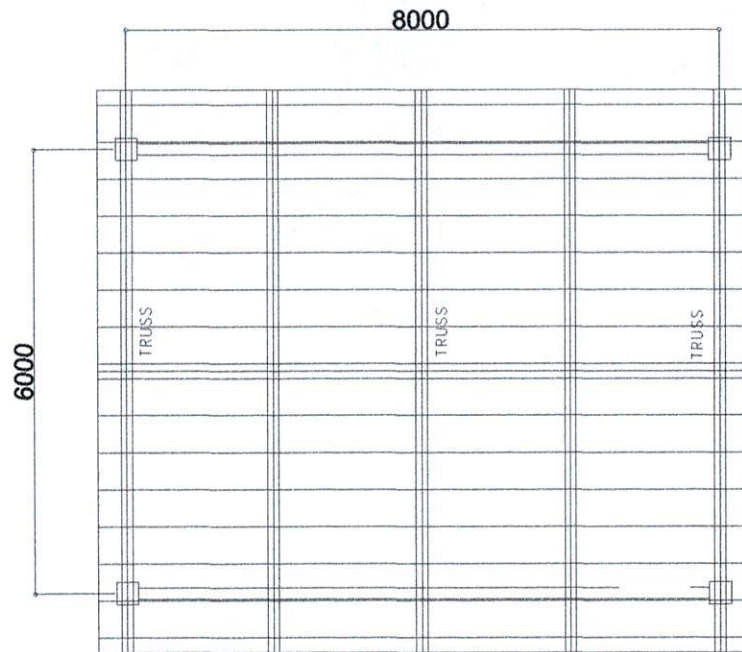

ROOF FRAMING PLAN
SCALE: 1:250

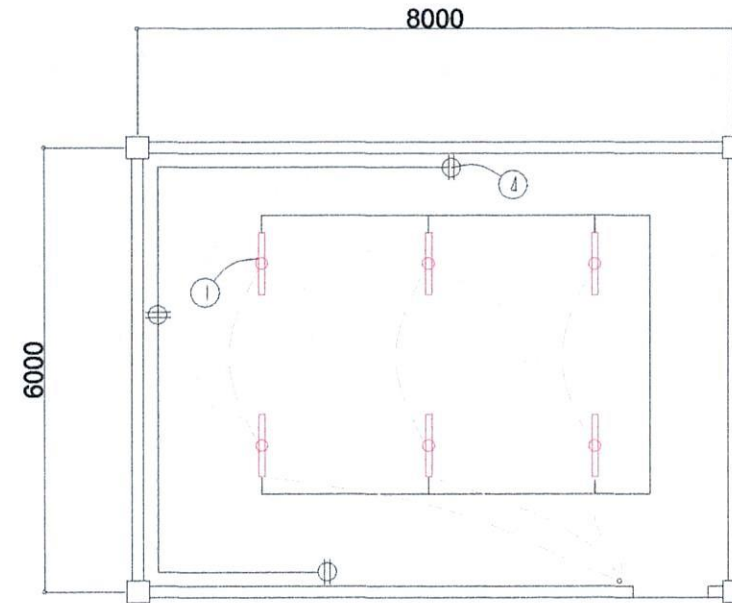

ELECTRICAL PLAN
SCALE: 1:250

ELECTRICAL NOTES

ALL ELECTRICAL WORKS SHALL BE DONE IN ACCORDANCE WITH THE LATEST RULES AND REGULATIONS OF THE PHIL. ELECTRICAL CODE AS WELL AS THE LOCAL AUTHORITY CONCERNED AND THE LOCAL POWER COMPANY.

ALL ELECTRICAL MATERIALS TO BE USED SHALL BE NEED & APPROVED TYPE FOR LOCATION & PURPOSE

MOUNTING HEIGHTS SHALL BE AS FOLLOWS:

- a. LIGHT CONTROL SWITCH- 1.35M ABOVE FIN. FLR. LINE AT CENTER
- b. CONVENIENCE OUTLET-ABOVE 1.0M ABOVE FIN. FLR. LINE AT CENTER
- c. PANEL BOARD- 2.0 M ABOVE FIN. FLR. LINE

ALL ELECTRICAL WORKS SHALL BE UNDER THE DIRECT & IMMEDIATE SUPERVISION OF A DULY LICENSED ELECTRICAL ENGINEER OR REGISTERED MASTER ELECTRICIAN

SCHEDULE OF LOADS

CIRCUIT NO.	DESCRIPTION	NO. OF LOADS	VOLTS	WATTS	AMP	SIZE OF WIRE	SIZE OF CONDUIT
1	LIGHTING OUTLET	6	230	600	2.60	2-2.0mm ² THW	15mmØ
2	CONVENIENCE OUTLET	3	230	540	2.34	2-3.5mm ² THW	20mmØ
	TOTAL				4.94		

RM. 10



CITY ENGINEER'S
OFFICE

PROJECT TITLE:

REPAIR/IMPROV. OF MULTI-PURPOSE HALL
(RIZAL ELEMENTARY SCHOOL)

LOC: BRGY. RIZAL, WEST DISTRICT

SORSOGON CITY

DRAWN BY:

Ma Pamela Legaspi

DRAFTING AIDE

RECOMMENDING APPROVAL :


ROEL D. BOMER C.E./RMP
CITY ENGINEER

APPROVED BY:

MA. ESTER E. HAMOR
CITY MAYOR

Floor plan of a room with dimensions and a central text label. The room is rectangular with a central area labeled "SCOPE OF WORK: CEILING, WINDOWS, DOORS". The dimensions are as follows:

- Overall width: 3670
- Overall height: 3650
- Top wall segments: 2620, 2600, 2500, 2600
- Bottom wall segments: 2600, 1800, 1300, 2600, 1300, 1000
- Door widths: 1300 (left), 1000 (right)
- Internal vertical dimensions: 3400, 2500
- Internal horizontal dimensions: 4000, 3370, 4900

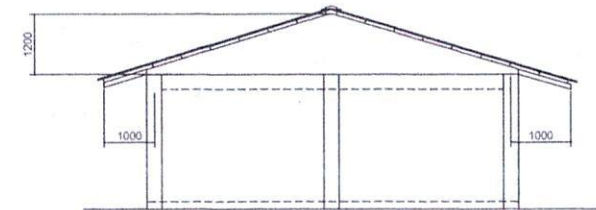

METAL DOUBLE FURRING CHANNEL (NAILER) 12MM X 38MM X 54 X 0.8MM THK • 1200MM O.C.

WALL ANGLE

METAL CARRYING CHANNEL (CEILING JOIST) (NAILER) 12MM X 38MM X 54 X 0.8MM THK • 800MM O.C.


ROD SUSPENSION HANGER WITH ADJUSTMENT SPRING

PREFORMED WIRE CLIP

MARINE PLYWOOD

CEILING DETAILS

SCALE

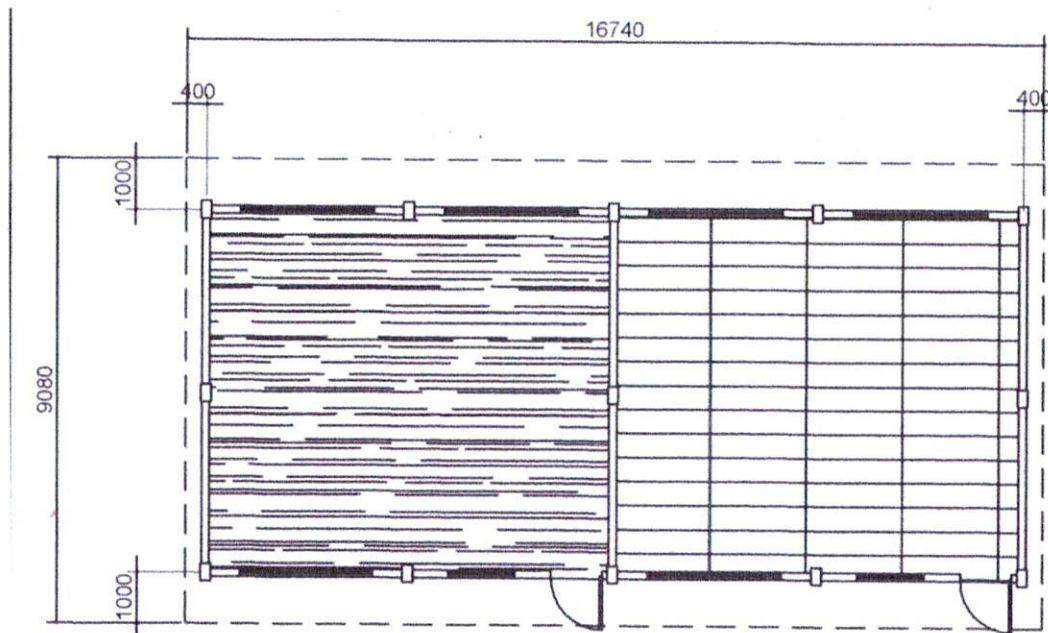

PROJECT TITLE:


DRAWN BY:

RECOMMENDING APPROVAL :

APPROVED BY:

MA. ESTER E. HAMOR
CITY MAYOR

LYDIA D. MARTINEZ MEMORIAL HIGH SCHOOL
A1 BLDG.

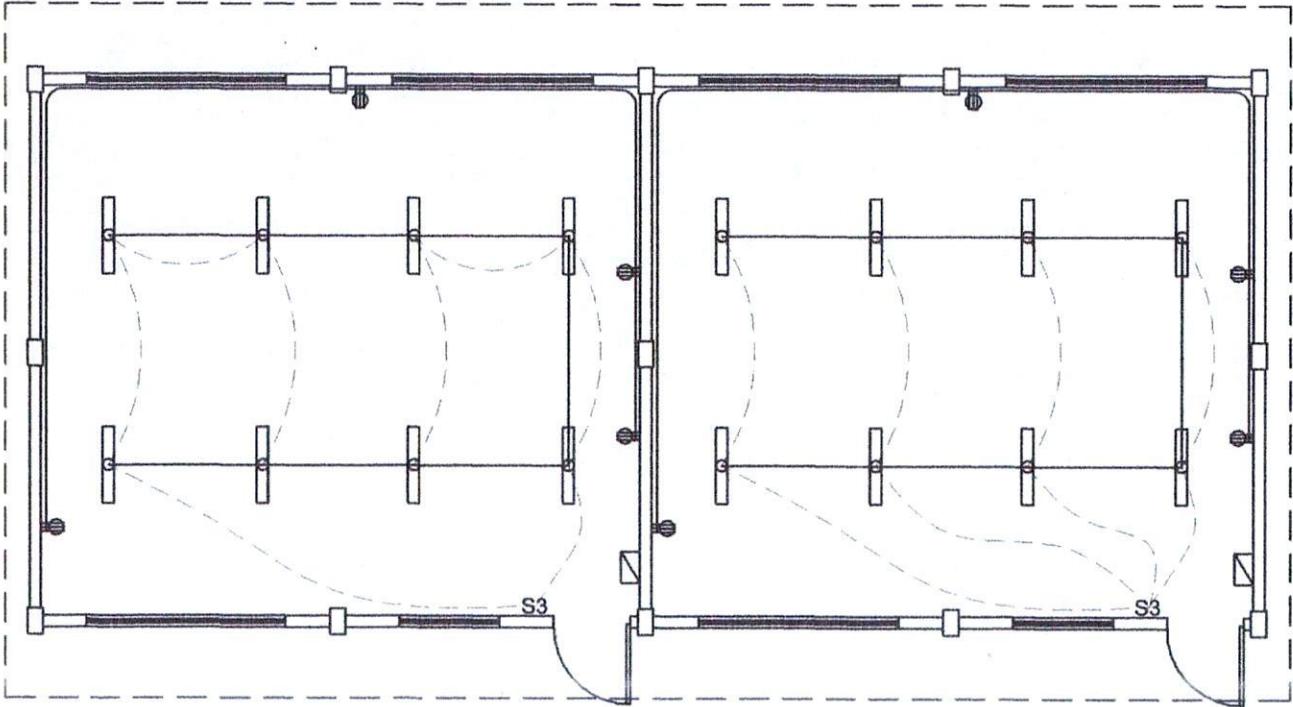

SCHEDULE OF LOADS						
CIRCUIT NO.	DESCRIPTION	NO. OF LOADS	VOLTS	WATTS	AMP	SIZE OF WIRE
1	LIGHTING OUTLET	8	230	800	3.47	2-2.0mm ² THW
2	CONVENIENCE OUTLET	4	230	720	3.13	2-3.5mm ² THW
	TOTAL	12		1520	6.6	SIZE OF CONDUIT

TOTAL VA = 1520 VA

IT = 1520 VA (100 %) DF
230 V
=6.60 A

ELECTRICAL NOTES

ALL ELECTRICAL WORKS SHALL BE DONE IN ACCORDANCE WITH THE LATEST RULES AND REGULATIONS OF THE PHIL. ELECTRICAL CODE AS WELL AS THE LOCAL AUTHORITY CONCERNED AND THE LOCAL POWER COMPANY.

ALL ELECTRICAL MATERIALS TO BE USED SHALL BE NEED & APPROVED TYPE FOR LOCATION & PURPOSE

MOUNTING HEIGHTS SHALL BE AS FOLLOWS:

- a. LIGHT CONTROL SWITCH- 1.35M ABOVE FIN. FLR. LINE AT CENTER
- b. CONVENIENCE OUTLET-ABOVE 1.0M ABOVE FIN. FLR. LINE AT CENTER
- c. PANEL BOARD- 2.0 M ABOVE FIN. FLR. LINE

ALL ELECTRICAL WORKS SHALL BE UNDER THE DIRECT & IMMEDIATE SUPERVISION OF A DULY LICENSED ELECTRICAL ENGINEER OR REGISTERED MASTER ELECTRICIAN



CITY ENGINEER'S
O F F I C E

PROJECT TITLE:

REPAIR/IMPROV. OF MULTI-PURPOSE HALL
(A1 BUILDING)

LOC: BRGY. SUGOD, BACON DISTRICT
SORSOGON CITY

DRAWN BY:



MaPamela Legaspi
DRAFTING AIDE

RECOMMENDING APPROVAL :

ROEL D. DOMER, C.E./RMP
CITY ENGINEER


APPROVED BY:

MA. ESTER E. HAMOR
CITY MAYOR

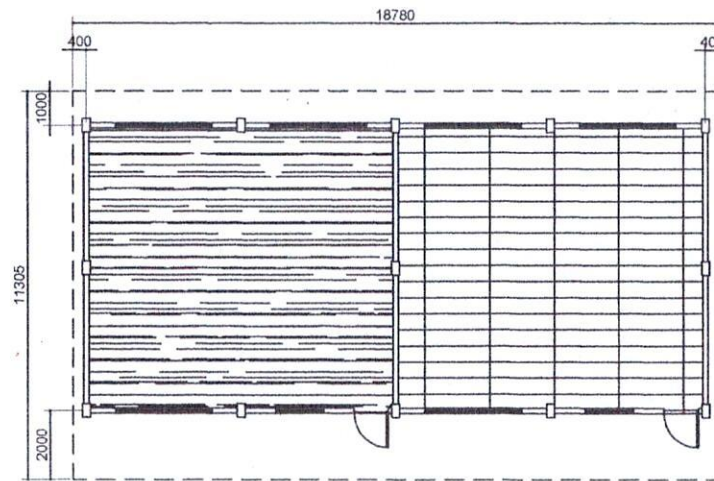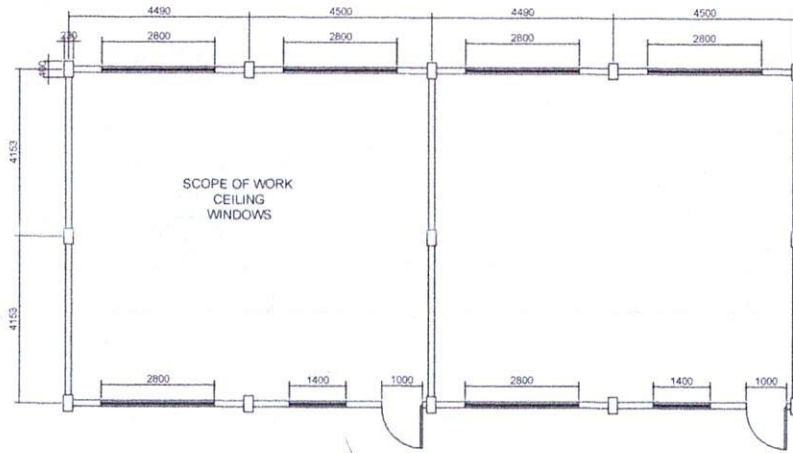

CEILING PLAN
SCALE: N T S

LYDIA D. MARTINEZ MEMORIAL HIGH SCHOOL A2 BLDG.

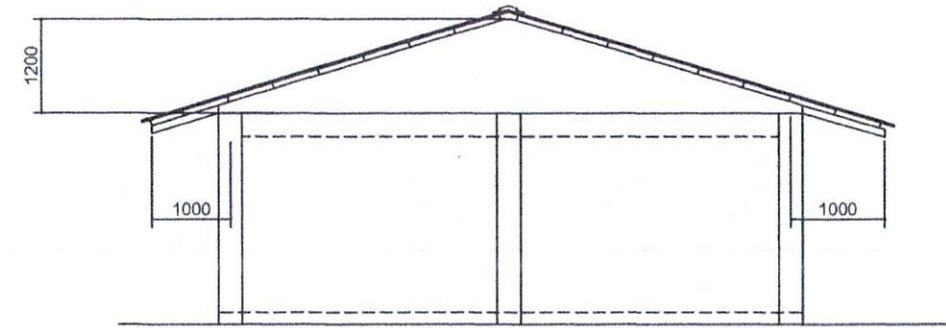

SIDE ELEVATION
SCALE: N T S

METAL DOUBLE FURRING CHANNEL
(NAILER) 12MM X 38MM X 5M X 0.8MM
THK @ 1200MM O.C.

METAL CARRYING CHANNEL (CEILING
JOIST) (NAILER) 12MM X 38MM X 5M X
0.8MM THK @ 400MM O.C.

WALL ANGLE

ROD SUSPENSION HANGER
WITH ADJUSTMENT SPRING

PREFORMED WIRE CLIP

MARINE PLYWOOD

CEILING DET.
SCALE: N T S



CITY ENGINEER'S
OFFICE

PROJECT TITLE:

REPAIR/IMPROV. OF MULTI-PURPOSE HALL
(A2 BUILDING)

LOC: BRGY. SUGOD, BACON DISTRICT

SORSOGON CITY

DRAWN BY:

MaPamelaLegaspi

DRAFTING AIDE


RECOMMENDING APPROVAL :

ROEL B. DOMER, C.E./RMP
CITY ENGINEER

APPROVED BY:

MA. ESTER E. HAMOR
CITY MAYOR

LYDIA D. MARTINEZ MEMORIAL HIGH SCHOOL
A2 BLDG.

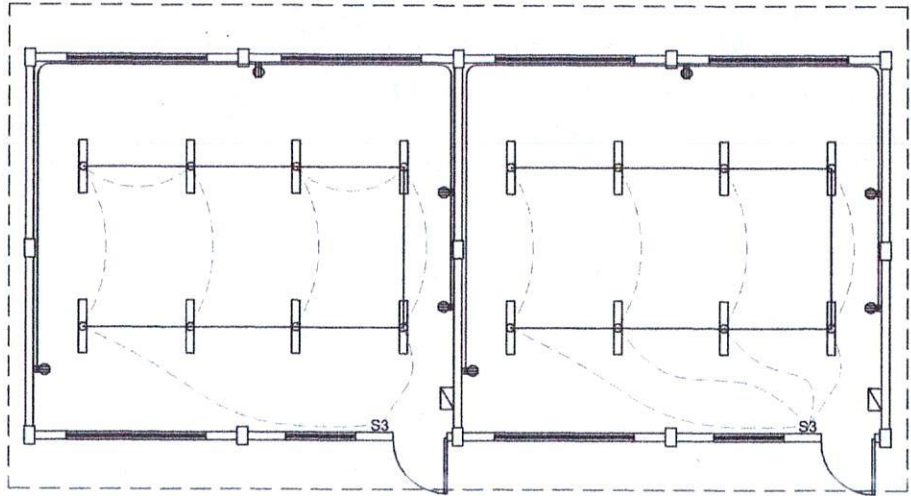

SCHEDULE OF LOADS

CIRCUIT NO.	DESCRIPTION	NO. OF LOADS	VOLTS	WATTS	AMP	SIZE OF WIRE	SIZE OF CONDUIT
1	LIGHTING OUTLET	8	230	800	3.47	2-2.0mm ² THW	15mmØ
2	CONVENIENCE OUTLET	4	230	720	3.13	2-3.5mm ² THW	20mmØ
	TOTAL				6.6		

ELECTRICAL NOTES

ALL ELECTRICAL WORKS SHALL BE DONE IN ACCORDANCE WITH THE LATEST RULES AND REGULATIONS OF THE PHIL. ELECTRICAL CODE AS WELL AS THE LOCAL AUTHORITY CONCERNED AND THE LOCAL POWER COMPANY.

ALL ELECTRICAL MATERIALS TO BE USED SHALL BE NEED & APPROVED TYPE FOR LOCATION & PURPOSE

MOUNTING HEIGHTS SHALL BE AS FOLLOWS:

- a. LIGHT CONTROL SWITCH- 1.35M ABOVE FIN. FLR. LINE AT CENTER
- b. CONVENIENCE OUTLET-ABOVE 1.0M ABOVE FIN. FLR. LINE AT CENTER
- c. PANEL BOARD- 2.0 M ABOVE FIN. FLR. LINE


ALL ELECTRICAL WORKS SHALL BE UNDER THE DIRECT & IMMEDIATE SUPERVISION OF A DULY LICENSED ELECTRICAL ENGINEER OR REGISTERED MASTER ELECTRICIAN




CITY ENGINEER'S
O F F I C E

PROJECT TITLE:	DRAWN BY:	RECOMMENDING APPROVAL :	APPROVED BY:
REPAIR/IMPROV. OF MULTI-PURPOSE HALL (A2 BUILDING)			
LOC: BRGY. SUGOD, BACON DISTRICT	MaPamela Legaspi	ROEL D. DOMER, C.E./RMP	MA. ESTER E. HAMOR
SORSOGON CITY	DRAFTING AIDE	CITY ENGINEER	CITY MAYOR


LYDIA D. MARTINEZ MEMORIAL HIGH SCHOOL
A3 BLDG.

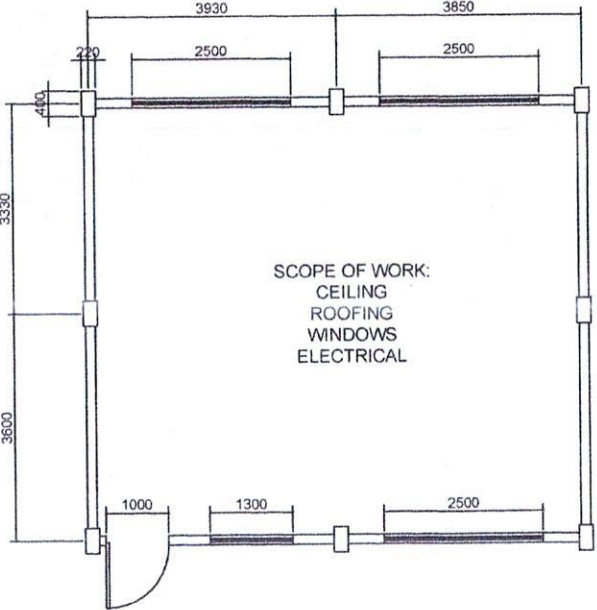

FLOOR PLAN
SCALE: 1:25M.TS

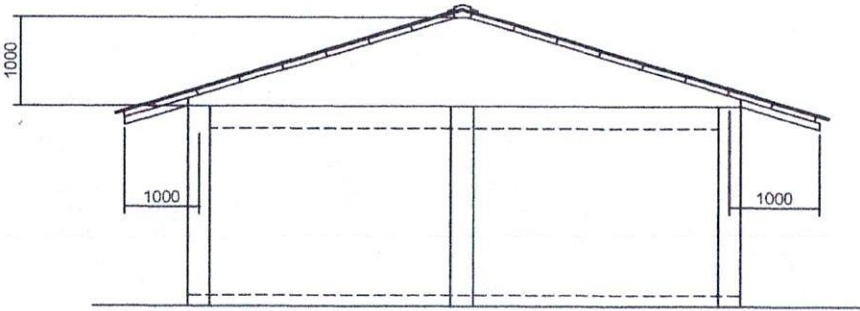


SIDE ELEVATION
SCALE: N T S

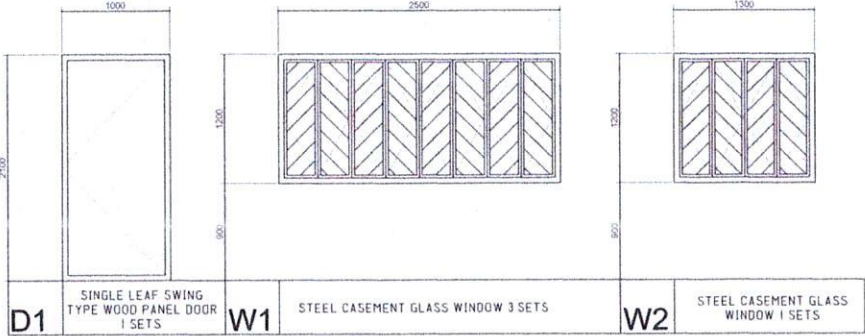


CITY ENGINEER'S
O F F I C E

PROJECT TITLE:	DRAWN BY:	RECOMMENDING APPROVAL :	APPROVED BY:
REPAIR/IMPROV. OF MULTI-PURPOSE HALL (A3 BUILDING)			
LOC: BRGY. SUGOD, BACON DISTRICT	Ma Pamela Legaspi	ROEL D. DOMER, C.E./RMP	MA. ESTER E. HAMOR
SORSOGON CITY	DRAFTING AIDE	CITY ENGINEER	CITY MAYOR


LYDIA D. MARTINEZ MEMORIAL HIGH SCHOOL
A3 BLDG.

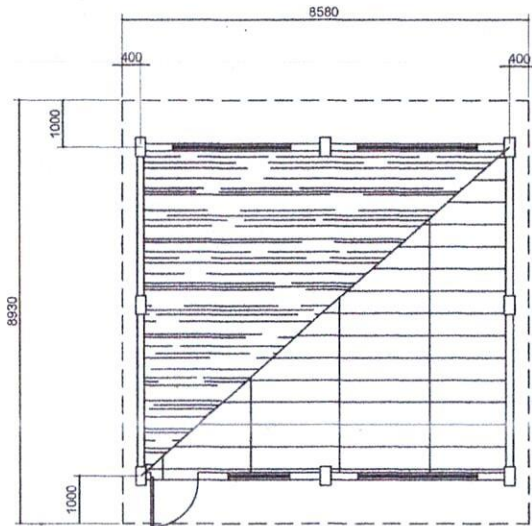

CEILING PLAN
SCALE: 1:25M.T.S.

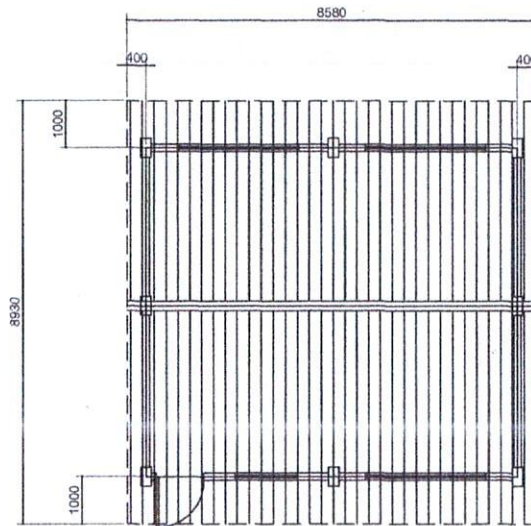


ROOF PLAN
SCALE: 1:25M.T.S.

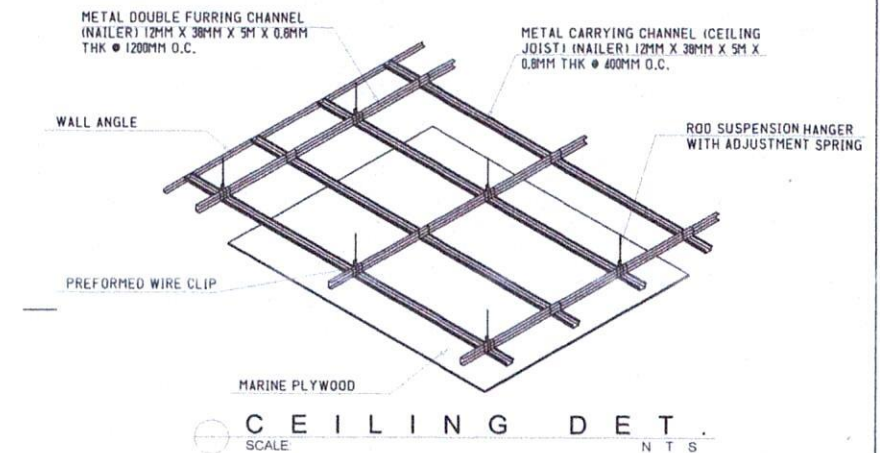

CITY ENGINEER'S
O F F I C E

PROJECT TITLE:	DRAWN BY:	RECOMMENDING APPROVAL :	APPROVED BY:
REPAIR/IMPROV. OF MULTI-PURPOSE HALL (A3 BUILDING)			
LOC: BRGY. SUGOD, BACON DISTRICT	Ma Pamela Legaspi	ROEL O. DOMER, C.E./RMP	MA. ESTER E. HAMOR
SORSOGON CITY	DRAFTING AIDE	CITY ENGINEER	CITY MAYOR

LYDIA D. MARTINEZ MEMORIAL HIGH SCHOOL
A3 BLDG.

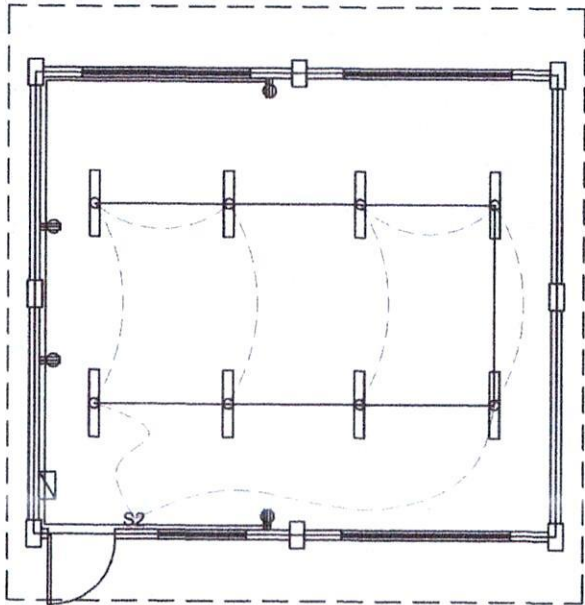

SCHEDULE OF LOADS

CIRCUIT NO.	DESCRIPTION	NO. OF LOADS	VOLTS	WATTS	AMP	SIZE OF WIRE	SIZE OF CONDUIT
1	LIGHTING OUTLET	8	230	800	3.47	2-2.0mm² THW	15mmØ
2	CONVENIENCE OUTLET	4	230	720	3.13	2-3.5mm² THW	20mmØ
TOTAL					6.6		

ELECTRICAL NOTES

ALL ELECTRICAL WORKS SHALL BE DONE IN ACCORDANCE WITH THE LATEST RULES AND REGULATIONS OF THE PHIL. ELECTRICAL CODE AS WELL AS THE LOCAL AUTHORITY CONCERNED AND THE LOCAL POWER COMPANY.

ALL ELECTRICAL MATERIALS TO BE USED SHALL BE NEED & APPROVED TYPE FOR LOCATION & PURPOSE

- MOUNTING HEIGHTS SHALL BE AS FOLLOWS:
- a. LIGHT CONTROL SWITCH- 1.35M ABOVE FIN. FLR. LINE AT CENTER
 - b. CONVENIENCE OUTLET-ABOVE 1.0M ABOVE FIN. FLR. LINE AT CENTER
 - c. PANEL BOARD- 2.0 M ABOVE FIN. FLR. LINE


ALL ELECTRICAL WORKS SHALL BE UNDER THE DIRECT & IMMEDIATE SUPERVISION OF A DULY LICENSED ELECTRICAL ENGINEER OR REGISTERED MASTER ELECTRICIAN




CITY ENGINEER'S
O F F I C E

PROJECT TITLE:	DRAWN BY:	RECOMMENDING APPROVAL :	APPROVED BY:
REPAIR/IMPROV. OF MULTI-PURPOSE HALL (A3 BUILDING)			
LOC: BRGY. SUGOD, BACON DISTRICT	MaPamelaLegaspi	ROEL D. BOMER, C.E./RMP	MA. ESTER E. HAMOR
SORSOGON CITY	DRAFTING AIDE	CITY ENGINEER	CITY MAYOR



LYDIA D. MARTINEZ MEMORIAL HIGH SCHOOL
A4 BLDG.

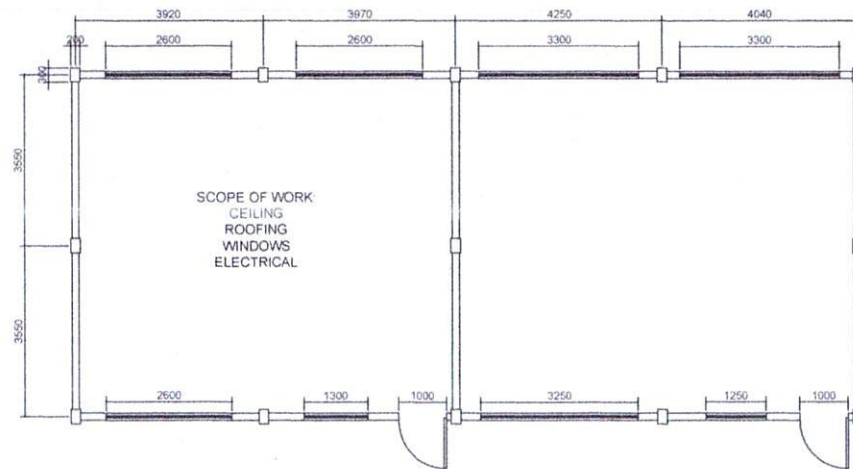

FLOOR PLAN
SCALE: 1:25MTS

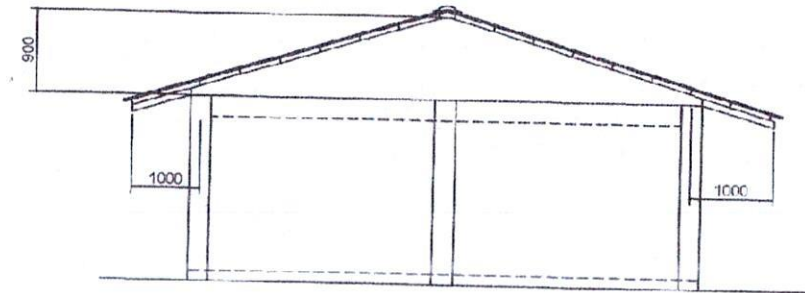


SIDE ELEVATION
SCALE: N T S

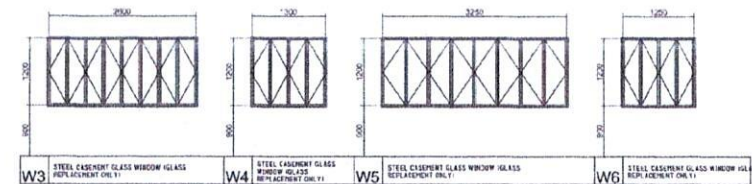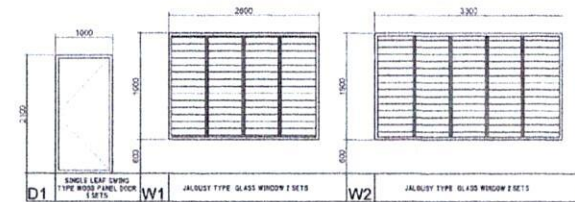


**CITY ENGINEER'S
OFFICE**

PROJECT TITLE:	DRAWN BY:	RECOMMENDING APPROVAL :	APPROVED BY:
REPAIR/IMPROV. OF MULTI-PURPOSE HALL (A4 BUILDING)			
LOC: BRGY. SUGOD, BACON DISTRICT	Ma Pamela Legaspi	ROEL D. DOMER, C.E./RMP	MA. ESTER E. HAMOR
SORSOGON CITY	DRAFTING AIDE	CITY ENGINEER	CITY MAYOR

LYDIA D. MARTINEZ MEMORIAL HIGH SCHOOL
A4 BLDG.

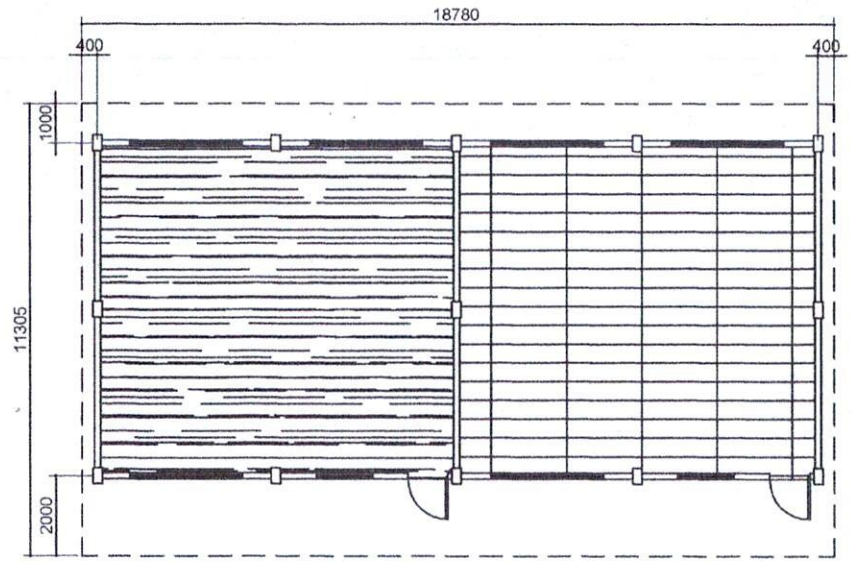

CEILING PLAN
SCALE: N T S

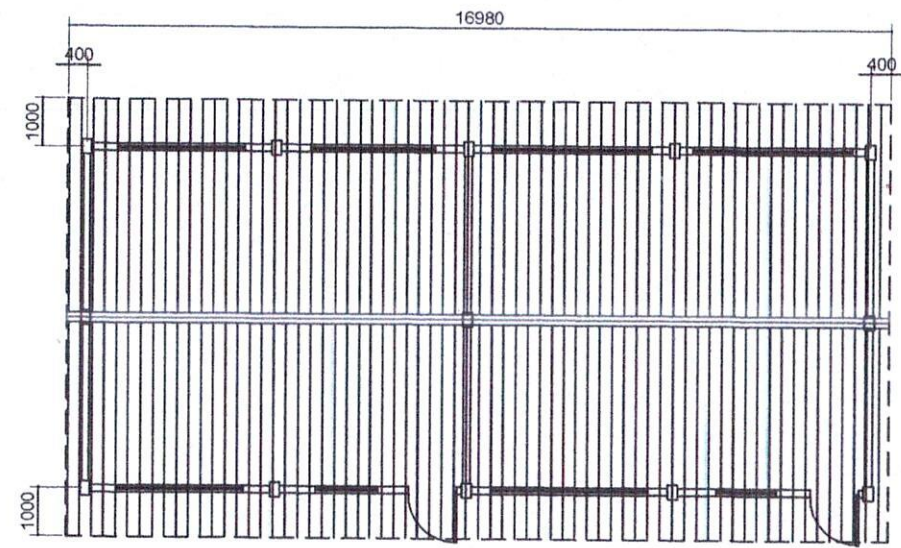


ROOF PLAN



CITY ENGINEER'S
OFFICE

PROJECT TITLE:	DRAWN BY:	RECOMMENDING APPROVAL :	APPROVED BY:
REPAIR/IMPROV. OF MULTI-PURPOSE HALL (A4 BUILDING)			
LOC: BRGY. SUGOD, BACON DISTRICT	Ma Pamela Legaspi	ROEL D. BOMER, C.E./RMP	MA. ESTER E. HAMOR
SORSOGON CITY	DRAFTING AIDE	CITY ENGINEER	CITY MAYOR

LYDIA D. MARTINEZ MEMORIAL HIGH SCHOOL
A4 BLDG.

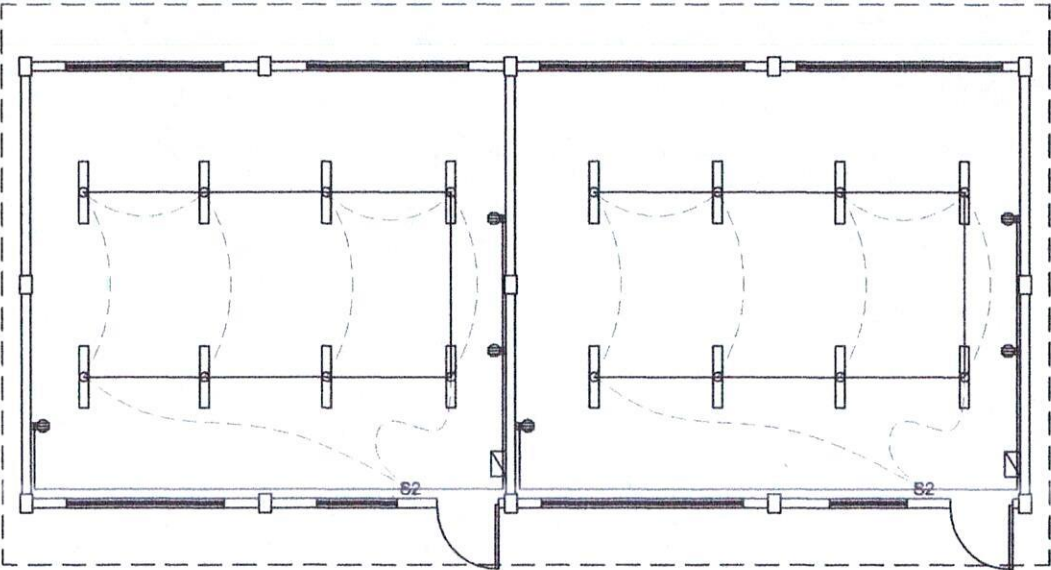

SCHEDULE OF LOADS							
CIRCUIT NO.	DESCRIPTION	NO. OF LOADS	VOLTS	WATTS	AMP	SIZE OF WIRE	SIZE OF CONDUIT
1	LIGHTING OUTLET	8	230	800	3.47	2-2.0mm² THW	15mmØ
2	CONVENIENCE OUTLET	3	230	540	2.34	2-3.5mm² THW	20mmØ
TOTAL					5.81		

ELECTRICAL NOTES

ALL ELECTRICAL WORKS SHALL BE DONE IN ACCORDANCE WITH THE LATEST RULES AND REGULATIONS OF THE PHIL. ELECTRICAL CODE AS WELL AS THE LOCAL AUTHORITY CONCERNED AND THE LOCAL POWER COMPANY.

ALL ELECTRICAL MATERIALS TO BE USED SHALL BE NEED & APPROVED TYPE FOR LOCATION & PURPOSE

- MOUNTING HEIGHTS SHALL BE AS FOLLOWS:
- a. LIGHT CONTROL SWITCH- 1.35M ABOVE FIN. FLR. LINE AT CENTER
 - b. CONVENIENCE OUTLET-ABOVE 1.0M ABOVE FIN. FLR. LINE AT CENTER
 - c. PANEL BOARD- 2.0 M ABOVE FIN. FLR. LINE


ALL ELECTRICAL WORKS SHALL BE UNDER THE DIRECT & IMMEDIATE SUPERVISION OF A DULY LICENSED ELECTRICAL ENGINEER OR REGISTERED MASTER ELECTRICIAN




CITY ENGINEER'S
O F F I C E

PROJECT TITLE:	DRAWN BY:	RECOMMENDING APPROVAL :	APPROVED BY:
REPAIR/IMPROV. OF MULTI-PURPOSE HALL (A4 BUILDING)			
LOC: BRGY. SUGOD, BACON DISTRICT	MaPamela Legaspi	ROEL D. DOMER, C.E./RMP	MA. ESTER E. HAMOR
SORSOGON CITY	DRAFTING AIDE	CITY ENGINEER	CITY MAYOR

LYDIA D. MARTINEZ MEMORIAL HIGH SCHOOL
A5 BLDG.

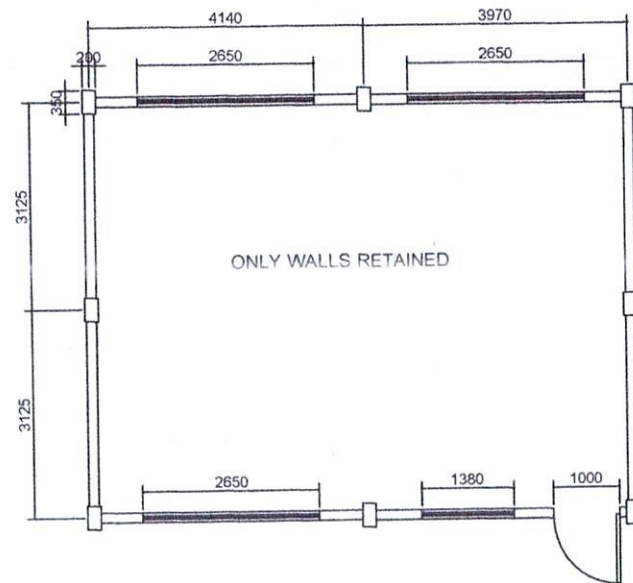

FLOOR PLAN
SCALE: 1:25MTS

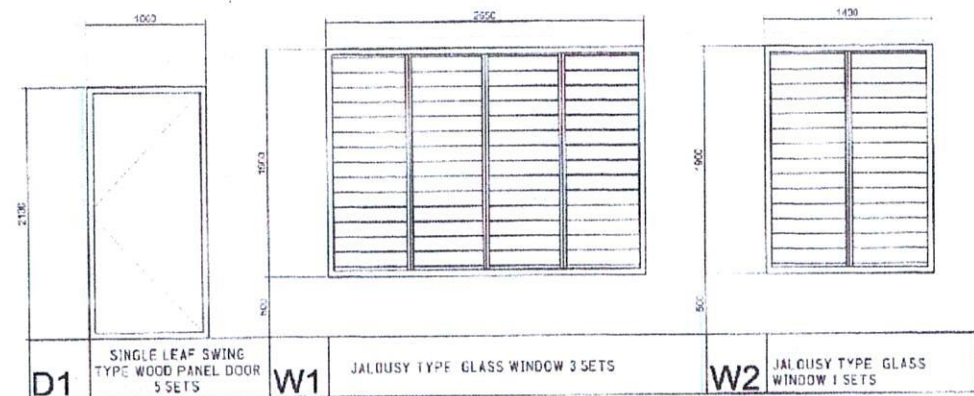

CITY ENGINEER'S
O F F I C E

PROJECT TITLE:

REPAIR/IMPROV. OF MULTI-PURPOSE HALL
(A5 BUILDING)

LOC: BRGY. SUGOD, BACON DISTRICT

SORSOGON CITY

DRAWN BY:

MaPamelaLegaspi

DRAFTING AIDE


RECOMMENDING APPROVAL:

ROEL D. DOMER, C.E./RMP
CITY ENGINEER


APPROVED BY:

MA. ESTER E. HAMOR
CITY MAYOR

LYDIA D. MARTINEZ MEMORIAL HIGH SCHOOL
A5 BLDG.

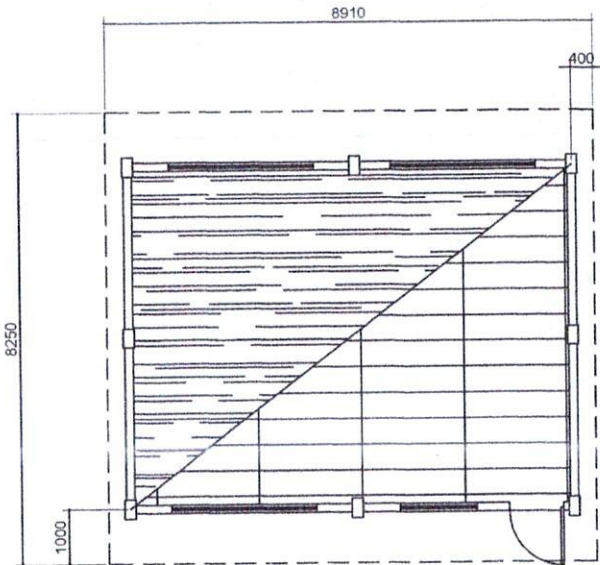

CEILING PLAN
SCALE: 1:25MTS

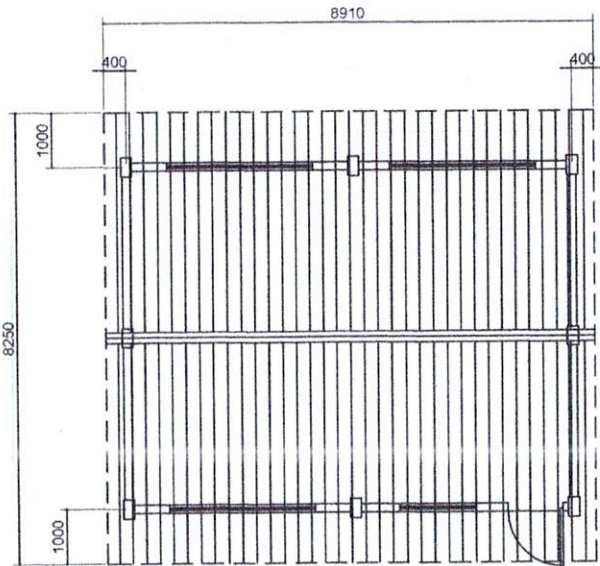


ROOF PLAN
SCALE: 1:25MTS



CITY ENGINEER'S
OFFICE

PROJECT TITLE:	DRAWN BY:	RECOMMENDING APPROVAL :	APPROVED BY:
REPAIR/IMPROV. OF MULTI-PURPOSE HALL (A5 BUILDING)			
LOC: BRGY. SUGOD, BACON DISTRICT SORSOGON CITY	MaPamelaLegaspi DRAFTING AIDE	ROEL D. DOMER, C.E./RMP CITY ENGINEER	MA. ESTER E. HAMOR CITY MAYOR

LYDIA D. MARTINEZ MEMORIAL HIGH SCHOOL
A5 BLDG.

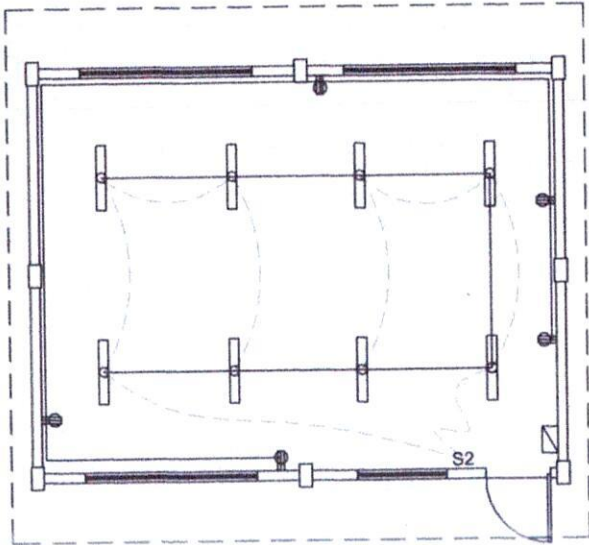

 **ELECTRICAL LAYOUT**
SCALE N T S

SCHEDULE OF LOADS							
CIRCUIT NO.	DESCRIPTION	NO. OF LOADS	VOLTS	WATTS	AMP	SIZE OF WIRE	SIZE OF CONDUIT
1	LIGHTING OUTLET	8	230	800	3.47	2-2.0mm ² THW	15mmØ
2	CONVENIENCE OUTLET	5	230	900	3.91	2-3.5mm ² THW	20mmØ
	TOTAL				7.38		

ELECTRICAL NOTES

ALL ELECTRICAL WORKS SHALL BE DONE IN ACCORDANCE WITH THE LATEST RULES AND REGULATIONS OF THE PHIL. ELECTRICAL CODE AS WELL AS THE LOCAL AUTHORITY CONCERNED AND THE LOCAL POWER COMPANY.

ALL ELECTRICAL MATERIALS TO BE USED SHALL BE NEED & APPROVED TYPE FOR LOCATION & PURPOSE

MOUNTING HEIGHTS SHALL BE AS FOLLOWS:

- a. LIGHT CONTROL SWITCH- 1.35M ABOVE FIN. FLR. LINE AT CENTER
- b. CONVENIENCE OUTLET-ABOVE 1.0M ABOVE FIN. FLR. LINE AT CENTER
- c. PANEL BOARD- 2.0 M ABOVE FIN. FLR. LINE

ALL ELECTRICAL WORKS SHALL BE UNDER THE DIRECT & IMMEDIATE SUPERVISION OF A DULY LICENSED ELECTRICAL ENGINEER OR REGISTERED MASTER ELECTRICIAN



**CITY ENGINEER'S
O F F I C E**

PROJECT TITLE:

REPAIR/IMPROV. OF MULTI-PURPOSE HALL
(A5 BUILDING)

LOC: BRGY. SUGOD, BACON DISTRICT
SORSOGON CITY

DRAWN BY:

MaPamelaLegaspi
DRAFTING AIDE




RECOMMENDING APPROVAL :

ROEL D. DOMER, C.E./RMP
CITY ENGINEER

APPROVED BY:

MA. ESTER E. HAMOR
CITY MAYOR


BLDG. 8 - FUR 2000

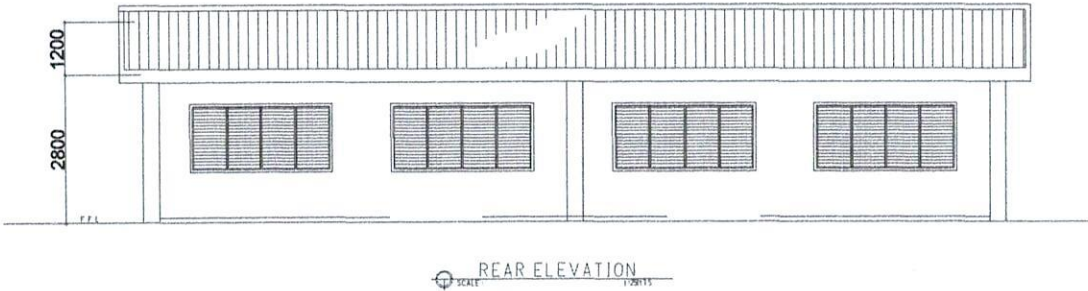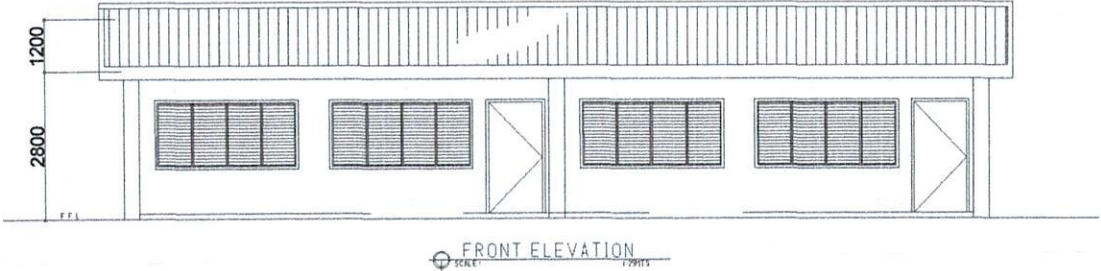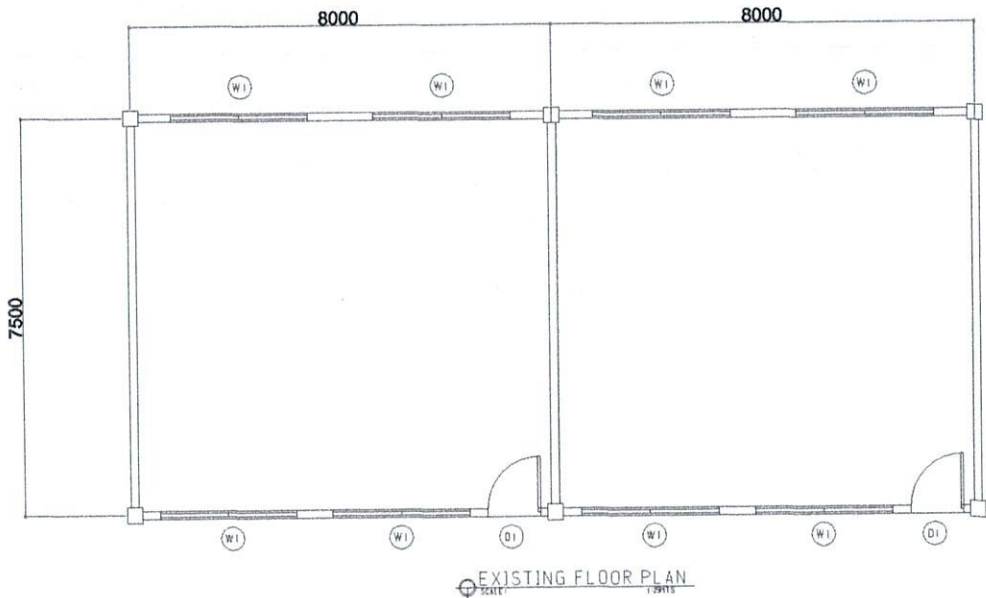


CITY ENGINEER'S
O F F I C E

PROJECT TITLE:	DRAWN BY:	RECOMMENDING APPROVAL :	APPROVED BY:
REPAIR/IMPROV. OF MULTI-PURPOSE HALL (OSIAO ELEM. SCHOOL)			
LOC: BRGY. OSIAO BACON DISTRICT SORSOGON CITY	MaPamelaLegaspi DRAFTING AIDE	ROEL D. DOMER, C.E./RMP CITY ENGINEER	MA. ESTER E. HAMOR CITY MAYOR


BLDG. 8 - FUR 2000

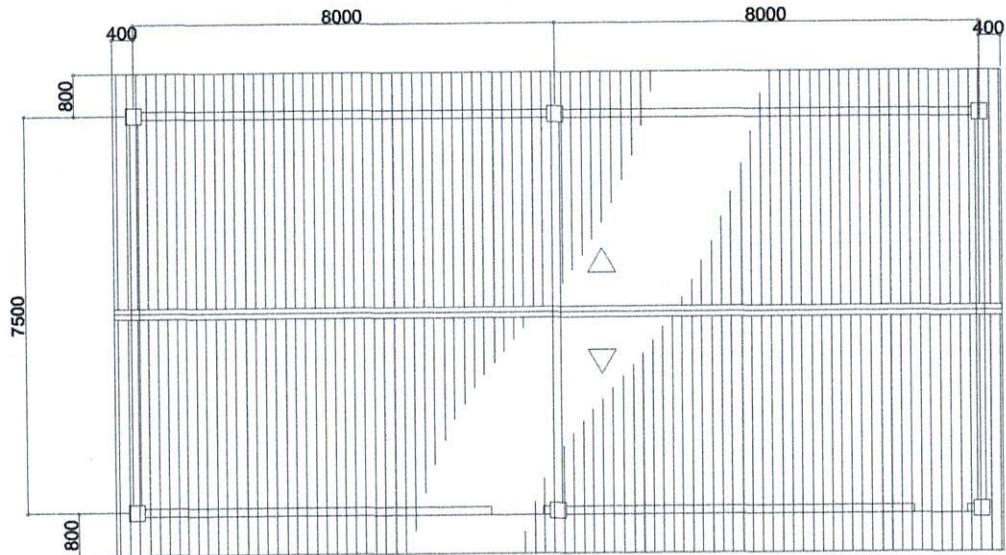


ROOF PLAN
SCALE: 1:200

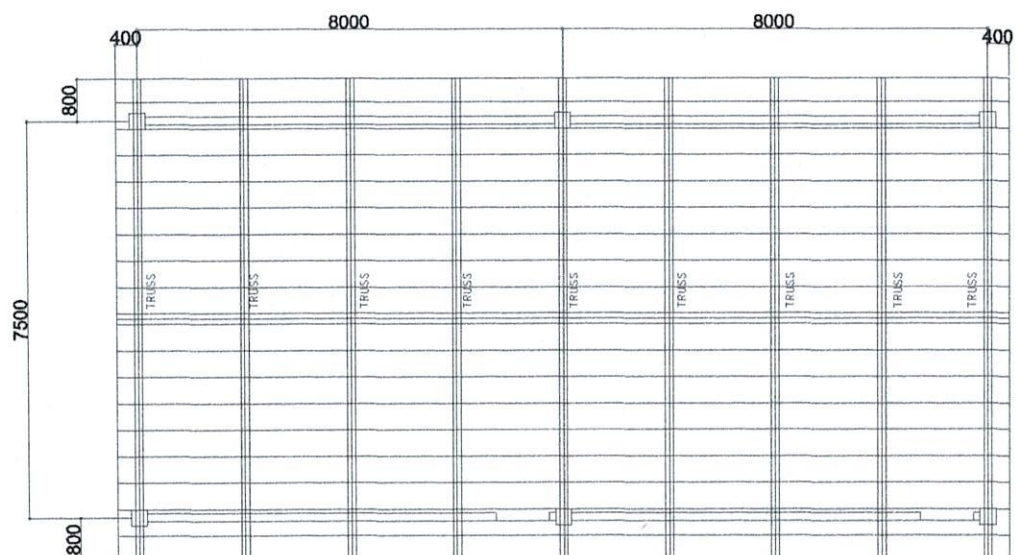

ROOF FRAMING PLAN
SCALE: 1:200

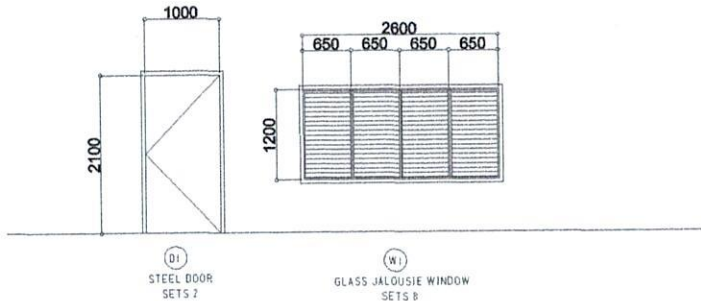

DOORS & WINDOWS SCHEDULE
SCALE: 1:200

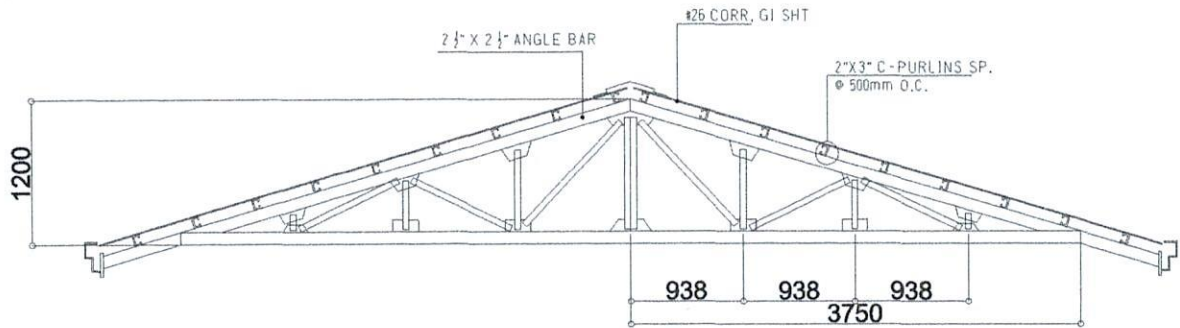



TRUSS DET.
SCALE: 1:80



CITY ENGINEER'S
OFFICE

PROJECT TITLE:	DRAWN BY:	RECOMMENDING APPROVAL:	APPROVED BY:
REPAIR/IMPROV. OF MULTI-PURPOSE HALL (OSIAO ELEM. SCHOOL)	MaPamelaLegaspi	ROEL D. DOMER, C.E./RMP	MA. ESTER E. HAMOR
LOC: BRGY. OSIAO BACON DISTRICT SORSOGON CITY	DRAFTING AIDE	CITY ENGINEER	CITY MAYOR

BLDG. 8 - FUR 2000

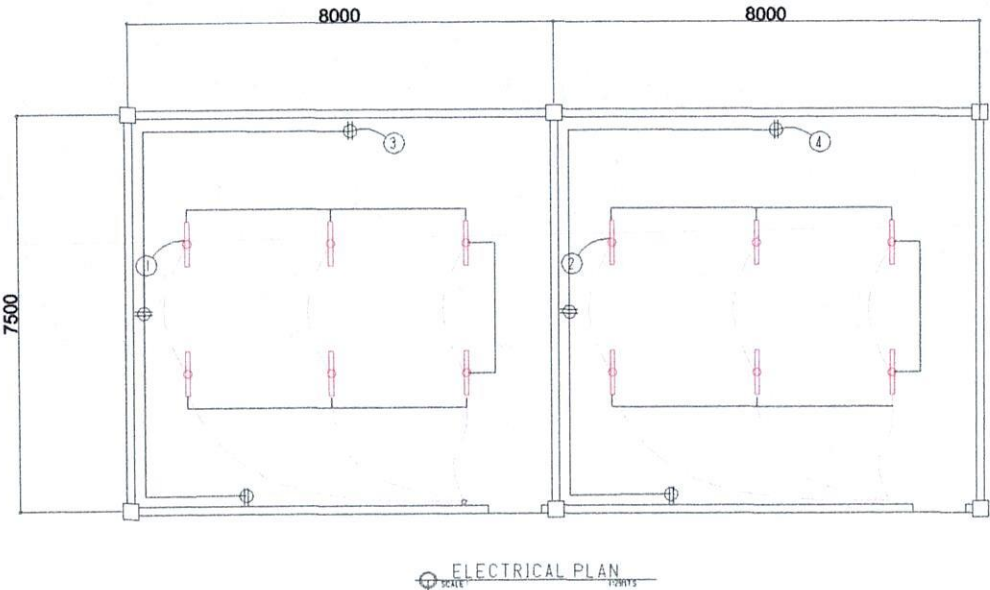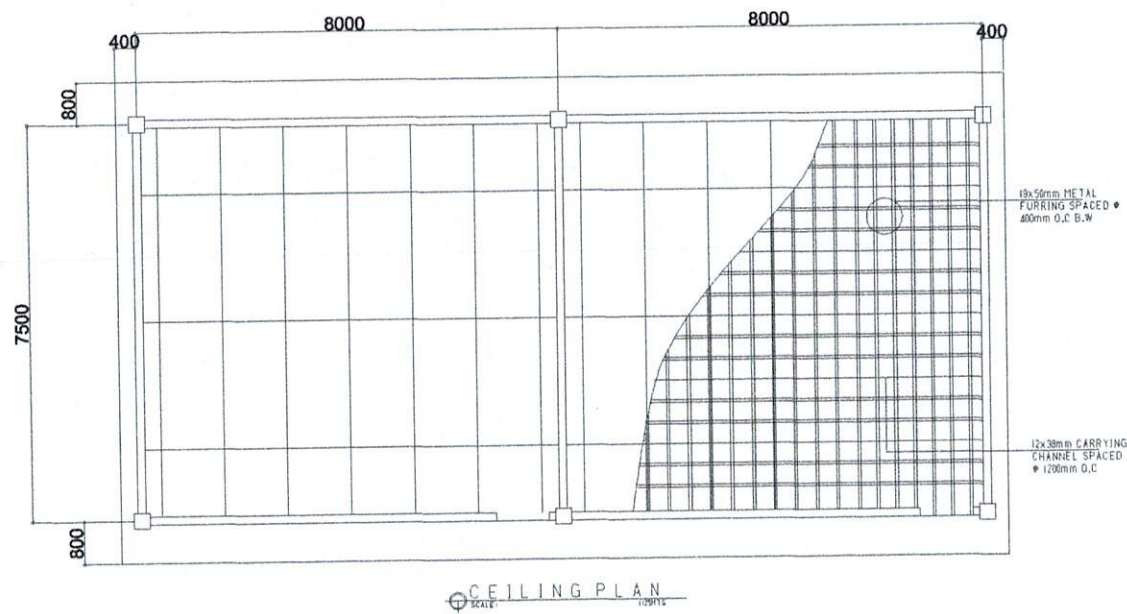

SCHEDULE OF LOADS

CIRCUIT NO.	DESCRIPTION	NO. OF LOADS	VOLTS	WATTS	AMP	SIZE OF WIRE	SIZE OF CONDUIT
1	LIGHTING OUTLET	6	230	600	2.60	2-2.0mm ² THW	15mmØ
2	LIGHTING OUTLET	6	230	600	2.60	2-2.0mm ² THW	15mmØ
3	CONVENIENCE OUTLET	3	230	540	2.34	2-3.5mm ² THW	20mmØ
4	CONVENIENCE OUTLET	3	230	540	2.34	2-3.5mm ² THW	20mmØ
TOTAL					9.88		

ELECTRICAL NOTES

ALL ELECTRICAL WORKS SHALL BE DONE IN ACCORDANCE WITH THE LATEST RULES AND REGULATIONS OF THE PHIL. ELECTRICAL CODE AS WELL AS THE LOCAL AUTHORITY CONCERNED AND THE LOCAL POWER COMPANY.

ALL ELECTRICAL MATERIALS TO BE USED SHALL BE NEED & APPROVED TYPE FOR LOCATION & PURPOSE

- MOUNTING HEIGHTS SHALL BE AS FOLLOWS:
- a. LIGHT CONTROL SWITCH- 1.35M ABOVE FIN. FLR. LINE AT CENTER
 - b. CONVENIENCE OUTLET-ABOVE 1.0M ABOVE FIN. FLR. LINE AT CENTER
 - c. PANEL BOARD- 2.0 M ABOVE FIN. FLR. LINE




ALL ELECTRICAL WORKS SHALL BE UNDER THE DIRECT & IMMEDIATE SUPERVISION OF A DULY LICENSED ELECTRICAL ENGINEER OR REGISTERED MASTER ELECTRICIAN



CITY ENGINEER'S
O F F I C E

PROJECT TITLE:	DRAWN BY:	RECOMMENDING APPROVAL:	APPROVED BY:
REPAIR/IMPROV. OF MULTI-PURPOSE HALL (OSIAO ELEM. SCHOOL)	Ma Pamela Legaspi	ROEL D. DOMER, C.E./RMP	MA. ESTER E. HAMOR
LOC: BRGY. OSIAO BACON DISTRICT SORSOGON CITY	DRAFTING AIDE	CITY ENGINEER	CITY MAYOR


PRINCIPAL OFFICE

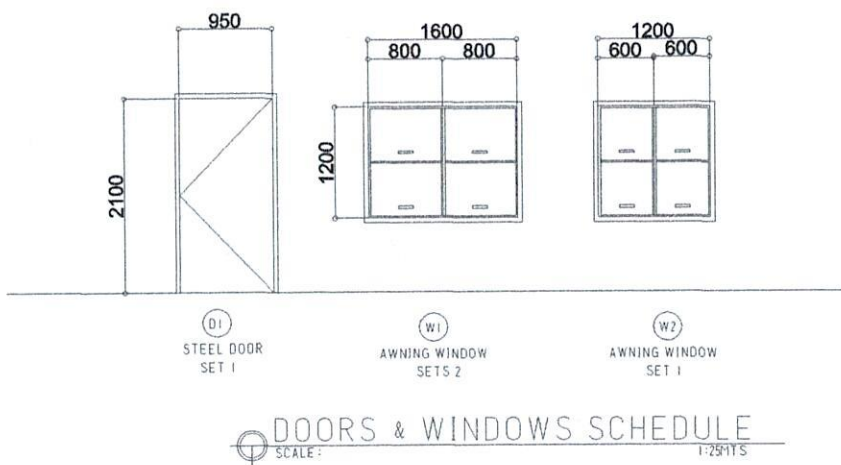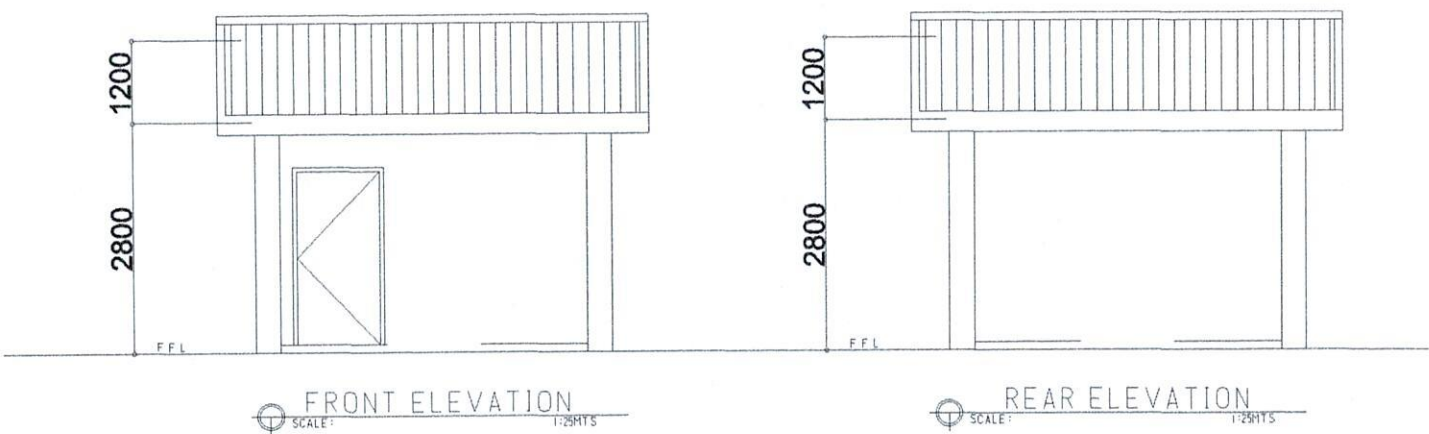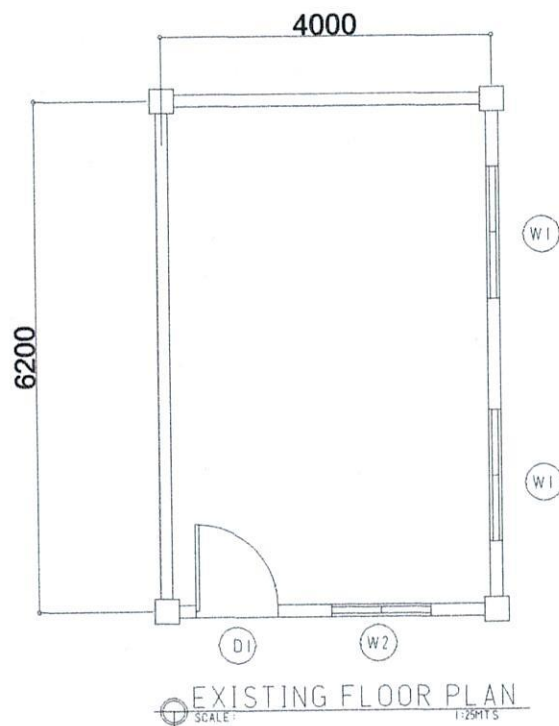


CITY ENGINEER'S
O F F I C E

PROJECT TITLE:	DRAWN BY:	RECOMMENDING APPROVAL :	APPROVED BY:
REPAIR/IMPROV. OF MULTI-PURPOSE HALL (OSIAO ELEM. SCHOOL)			
LOC: BRGY. OSIAO BACON DISTRICT SORSOGON CITY	Ma Pamela Legaspi DRAFTING AIDE	ROEL D. DOMER, C.E./RMP CITY ENGINEER	MA. ESTER E. HAMOR CITY MAYOR

PRINCIPAL OFFICE

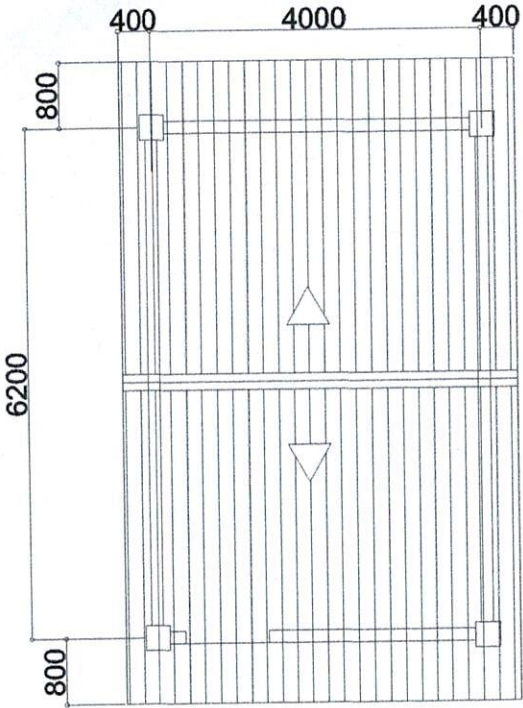


ROOF PLAN
SCALE: 1:25MTS

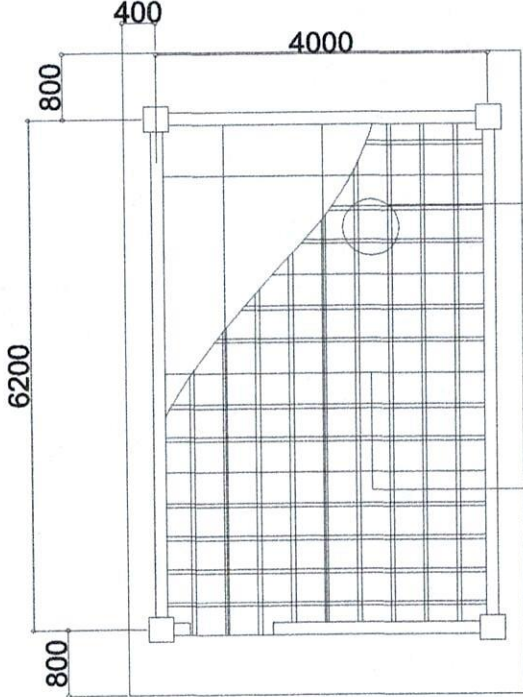


CEILING PLAN
SCALE: 1:25MTS

19x50mm METAL
FURRING SPACED @
400mm O.C B.W

12x38mm CARRYING
CHANNEL SPACED
@ 1200mm O.C

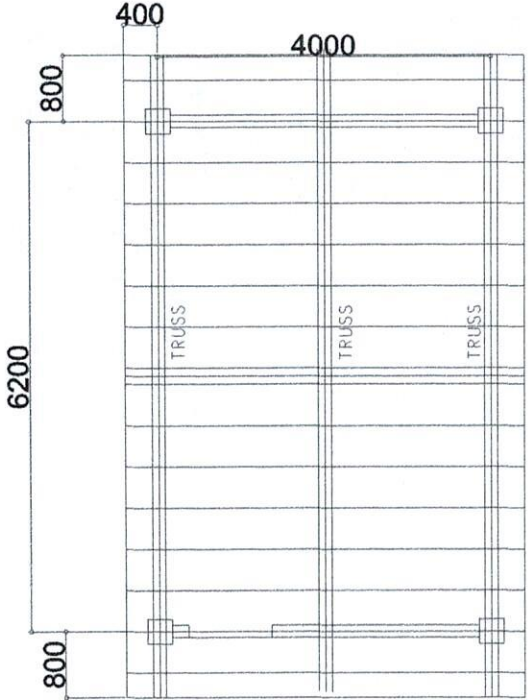


ROOF FRAMING PLAN
SCALE: 1:25MTS

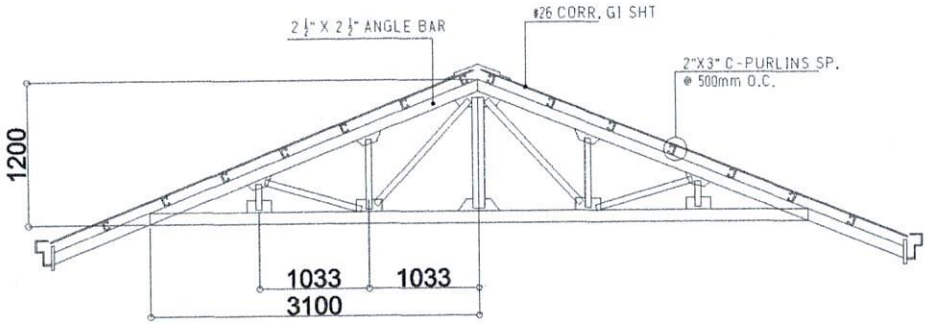

CITY ENGINEER'S
OFFICE

PROJECT TITLE:	DRAWN BY:	RECOMMENDING APPROVAL :	APPROVED BY:
REPAIR/IMPROV. OF MULTI-PURPOSE HALL (OSIAO ELEM. SCHOOL)			
LOC: BRGY. OSIAO BACON DISTRICT SORSOGON CITY	MaPamelaLegasp1 DRAFTING AIDE	ROEL D. DOMER, C.E./RMP CITY ENGINEER	MA. ESTER E. HAMOR CITY MAYOR

PRINCIPAL OFFICE

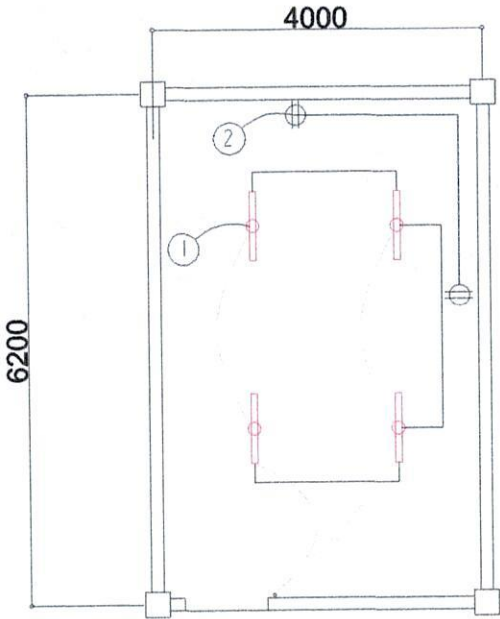

ELECTRICAL PLAN
SCALE: 1:250

SCHEDULE OF LOADS							
CIRCUIT NO.	DESCRIPTION	NO. OF LOADS	VOLTS	WATTS	AMP	SIZE OF WIRE	SIZE OF CONDUIT
1	LIGHTING OUTLET	6	230	600	2.60	2-2.0mm ² THW	15mmØ
2	CONVENIENCE OUTLET	2	230	360	1.56	2-3.5mm ² THW	20mmØ
TOTAL					4.16		

ELECTRICAL NOTES

ALL ELECTRICAL WORKS SHALL BE DONE IN ACCORDANCE WITH THE LATEST RULES AND REGULATIONS OF THE PHIL. ELECTRICAL CODE AS WELL AS THE LOCAL AUTHORITY CONCERNED AND THE LOCAL POWER COMPANY.

ALL ELECTRICAL MATERIALS TO BE USED SHALL BE NEED & APPROVED TYPE FOR LOCATION & PURPOSE

- MOUNTING HEIGHTS SHALL BE AS FOLLOWS:
- a. LIGHT CONTROL SWITCH- 1.35M ABOVE FIN. FLR. LINE AT CENTER
 - b. CONVENIENCE OUTLET-ABOVE 1.0M ABOVE FIN. FLR. LINE AT CENTER
 - c. PANEL BOARD- 2.0 M ABOVE FIN. FLR. LINE


ALL ELECTRICAL WORKS SHALL BE UNDER THE DIRECT & IMMEDIATE SUPERVISION OF A DULY LICENSED ELECTRICAL ENGINEER OR REGISTERED MASTER ELECTRICIAN




CITY ENGINEER'S
O F F I C E

PROJECT TITLE:	DRAWN BY:	RECOMMENDING APPROVAL :	APPROVED BY:
REPAIR/IMPROV. OF MULTI-PURPOSE HALL (OSIAO ELEM. SCHOOL)			
LOC: BRGY. OSIAO BACON DISTRICT SORSOGON CITY	MaPamelaLegaspi DRAFTING AIDE	ROEL D. DOMER, C.E./RMP CITY ENGINEER	MA. ESTER E. HAMOR CITY MAYOR


RP-US BAYANIHAN BLDG.

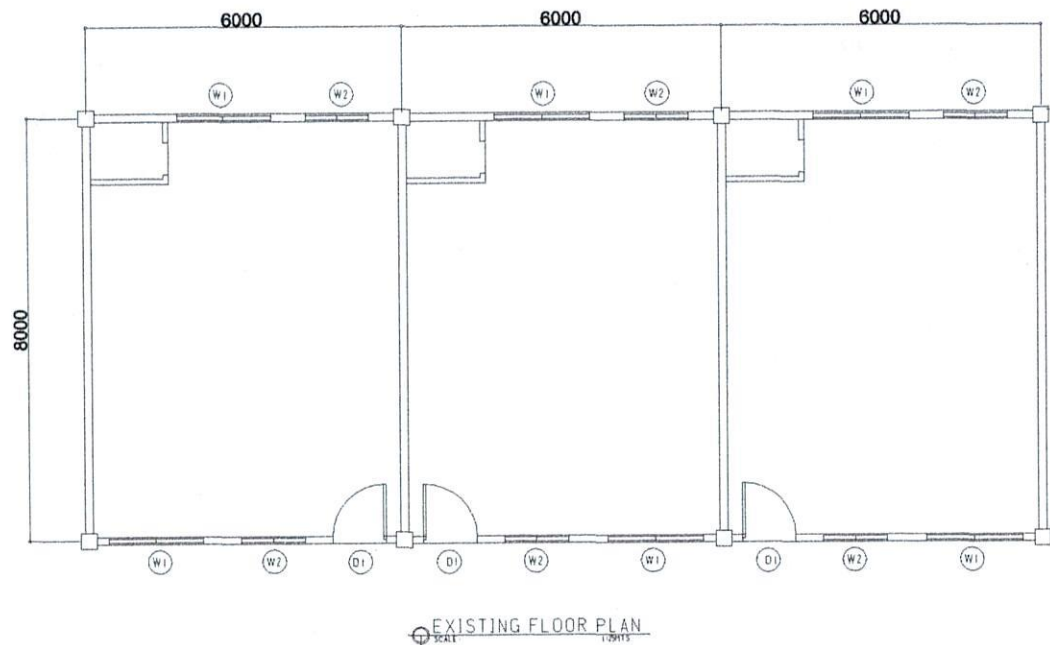

EXISTING FLOOR PLAN
SCALE 1:200

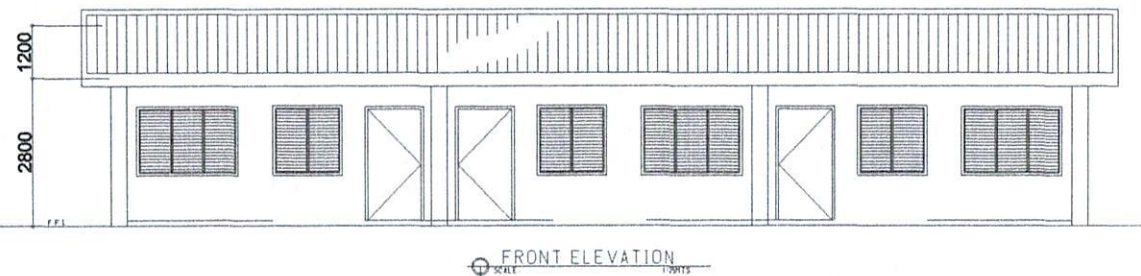

FRONT ELEVATION
SCALE 1:200

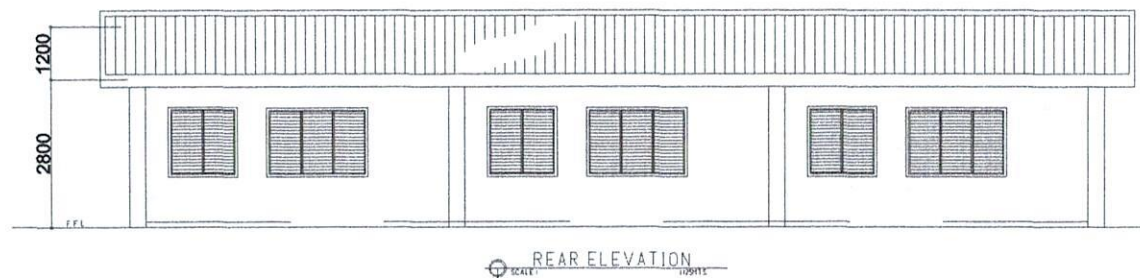


REAR ELEVATION
SCALE 1:200




CITY ENGINEER'S
O F F I C E

PROJECT TITLE:	DRAWN BY:	RECOMMENDING APPROVAL :	APPROVED BY:
REPAIR/IMPROV. OF MULTI-PURPOSE HALL (BACON WEST CENTRAL SCHOOL)			
LOC: BACON DISTRICT SORSOGON CITY	Ma Pamela Legaspi DRAFTING AIDE	ROEL D. BOMER, C.E./RMP CITY ENGINEER	MA. ESVER E. HAMOR CITY MAYOR


RP-US BAYANIHAN BLDG.

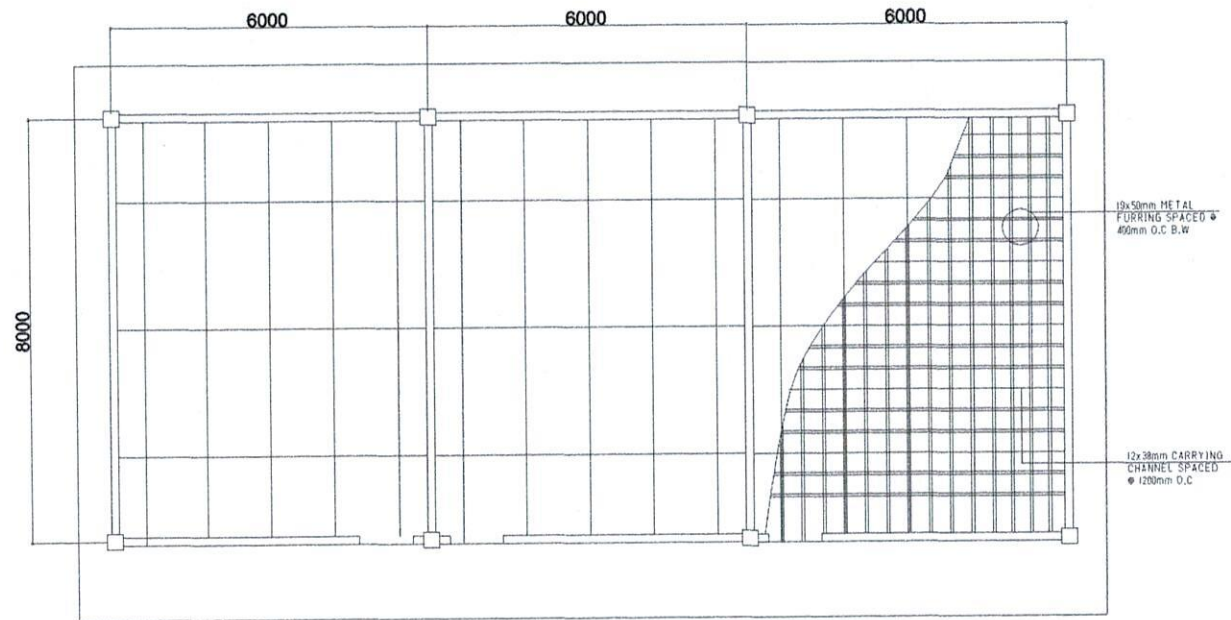

CEILING PLAN
SCALE: 1:25MTS

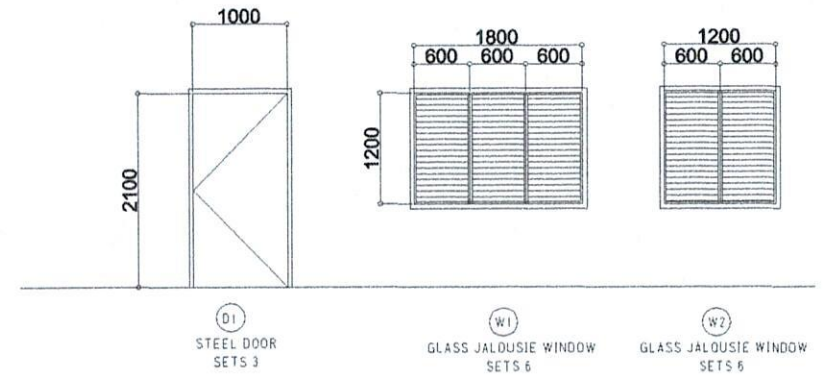

DOORS & WINDOWS SCHEDULE
SCALE: 1:25MTS

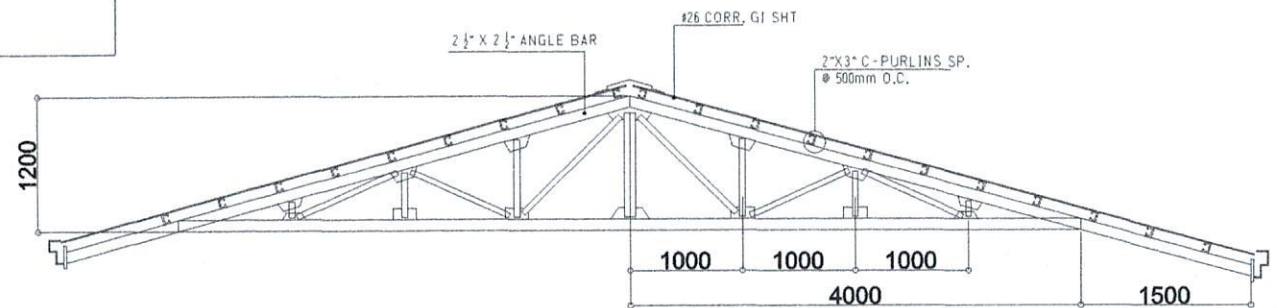

TRUSS DET.
SCALE: 1:80MTS



CITY ENGINEER'S
O F F I C E

PROJECT TITLE:

REPAIR/IMPROV. OF MULTI-PURPOSE HALL
(BACON WEST CENTRAL SCHOOL)

LOC: BACON DISTRICT

SORSOGON CITY

DRAWN BY:

MaPamelaLegaspi

DRAFTING AIDE



RECOMMENDING APPROVAL:

ROEL D. DOMER, C.E./RMP
CITY ENGINEER

APPROVED BY:

MA. ESTER E. HAMOR
CITY MAYOR


RP-US BAYANIHAN BLDG.

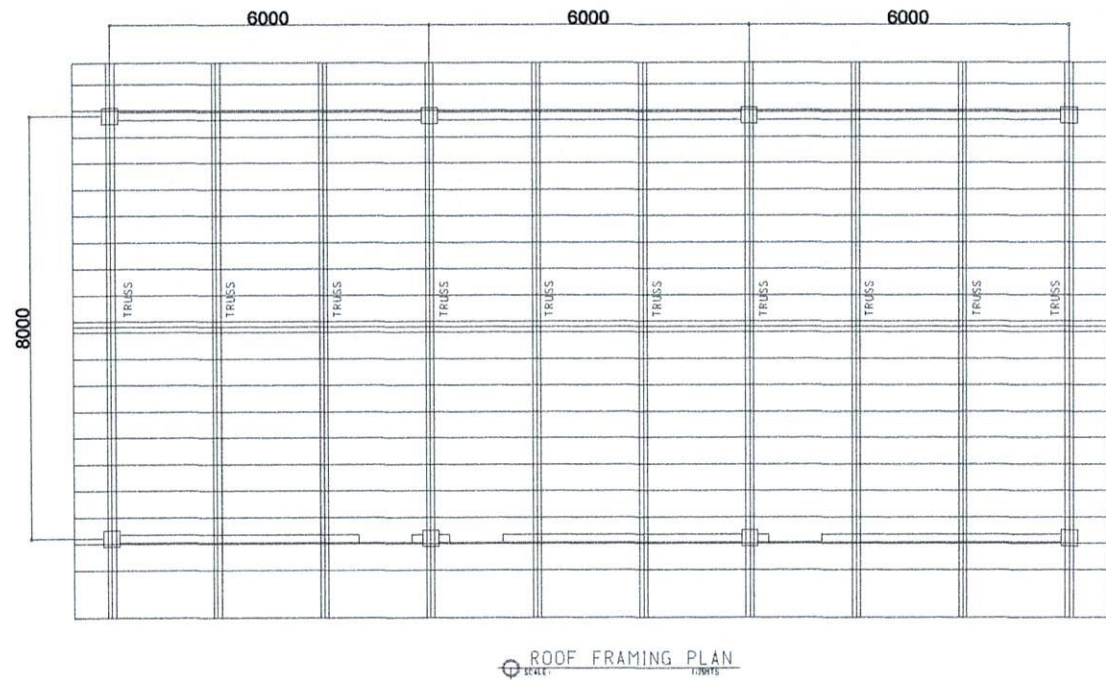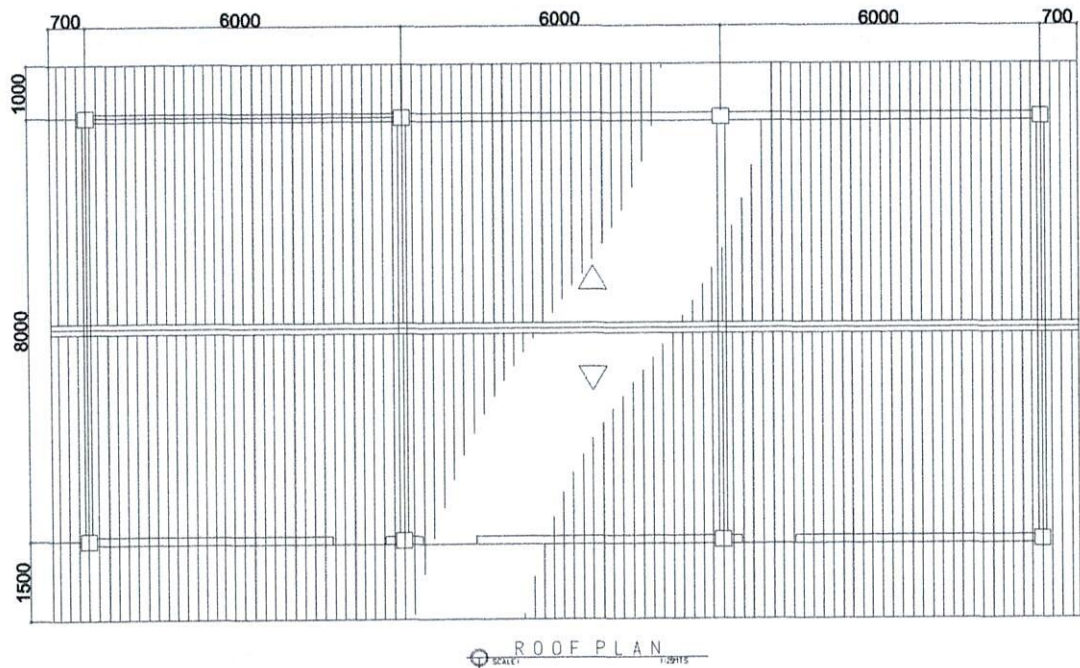

CITY ENGINEER'S
O F F I C E

PROJECT TITLE:	DRAWN BY:	RECOMMENDING APPROVAL :	APPROVED BY:
REPAIR/IMPROV. OF MULTI-PURPOSE HALL (BACON WEST CENTRAL SCHOOL)			
LOC: BACON DISTRICT	Ma Pamela Legaspi	ROEL D. DOMER / C.E./RMP	MA. ESTER E. HAMOR
SORSOGON CITY	DRAFTING AIDE	CITY ENGINEER	CITY MAYOR

RP-US BAYANIHAN BLDG.

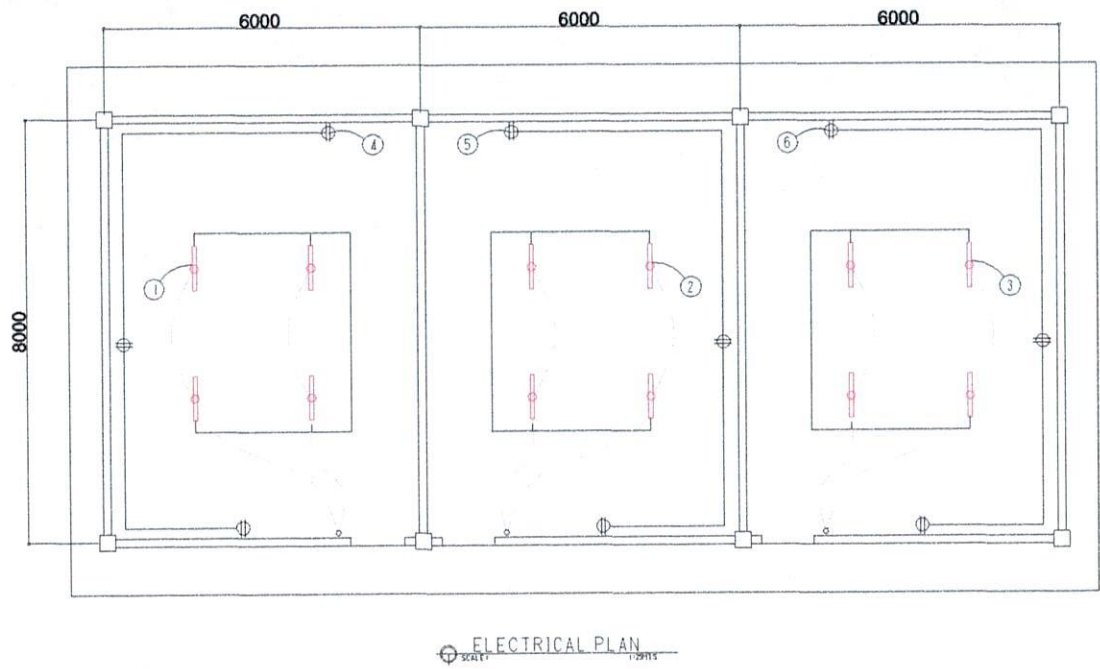

SCHEDULE OF LOADS							
CIRCUIT NO.	DESCRIPTION	NO. OF LOADS	VOLTS	WATTS	AMP	SIZE OF WIRE	SIZE OF CONDUIT
1	LIGHTING OUTLET	4	230	400	1.73	2-2.0mm² THW	15mmØ
2	LIGHTING OUTLET	4	230	400	1.73	2-2.0mm² THW	15mmØ
3	LIGHTING OUTLET	4	230	400	1.73	2-2.0mm² THW	15mmØ
4	CONVENIENCE OUTLET	3	230	540	2.34	2-3.5mm² THW	20mmØ
5	CONVENIENCE OUTLET	3	230	540	2.34	2-3.5mm² THW	20mmØ
6	CONVENIENCE OUTLET	3	230	540	2.34	2-3.5mm² THW	20mmØ
TOTAL					10.92		

ELECTRICAL NOTES

ALL ELECTRICAL WORKS SHALL BE DONE IN ACCORDANCE WITH THE LATEST RULES AND REGULATIONS OF THE PHIL. ELECTRICAL CODE AS WELL AS THE LOCAL AUTHORITY CONCERNED AND THE LOCAL POWER COMPANY.

ALL ELECTRICAL MATERIALS TO BE USED SHALL BE NEED & APPROVED TYPE FOR LOCATION & PURPOSE

MOUNTING HEIGHTS SHALL BE AS FOLLOWS:

- a. LIGHT CONTROL SWITCH- 1.35M ABOVE FIN. FLR. LINE AT CENTER
- b. CONVENIENCE OUTLET-ABOVE 1.0M ABOVE FIN. FLR. LINE AT CENTER
- c. PANEL BOARD- 2.0 M ABOVE FIN. FLR. LINE




ALL ELECTRICAL WORKS SHALL BE UNDER THE DIRECT & IMMEDIATE SUPERVISION OF A DULY LICENSED ELECTRICAL ENGINEER OR REGISTERED MASTER ELECTRICIAN



CITY ENGINEER'S
O F F I C E


PROJECT TITLE:	DRAWN BY:	RECOMMENDING APPROVAL :	APPROVED BY:
REPAIR/IMPROV. OF MULTI-PURPOSE HALL (BACON WEST CENTRAL SCHOOL)			
LOC: BACON DISTRICT	MaPamelaLegaspi	ROEL D. DOMER, C.E./RMP	MA. ESTER E. HAMOR
SORSOGON CITY	DRAFTING AIDE	CITY ENGINEER	CITY MAYOR

MARCOS TYPE BLDG.

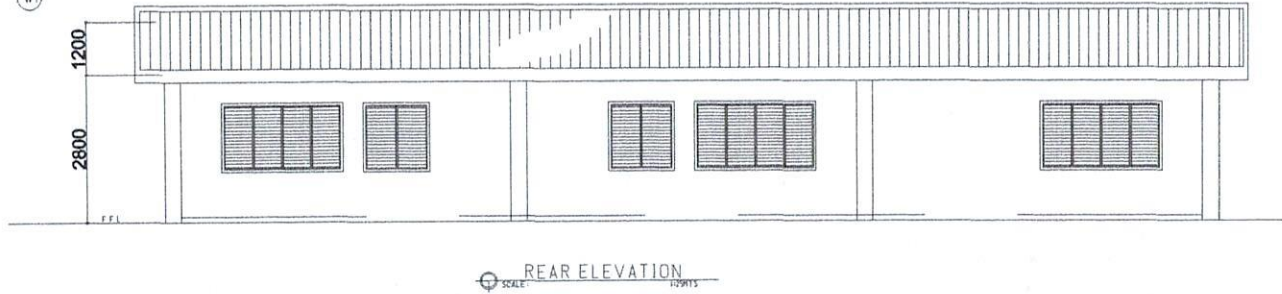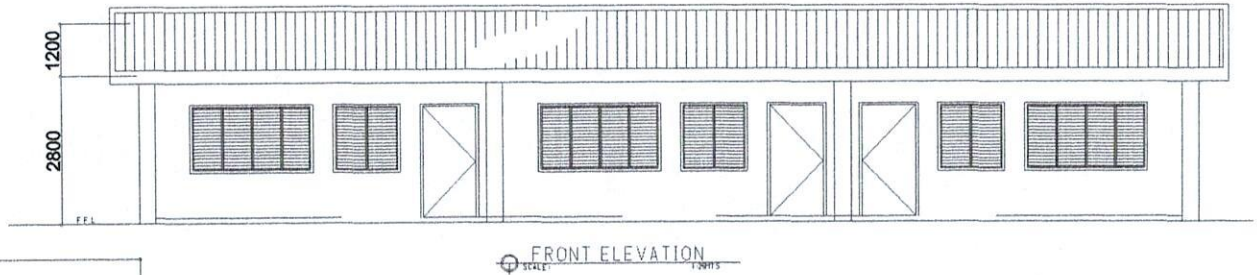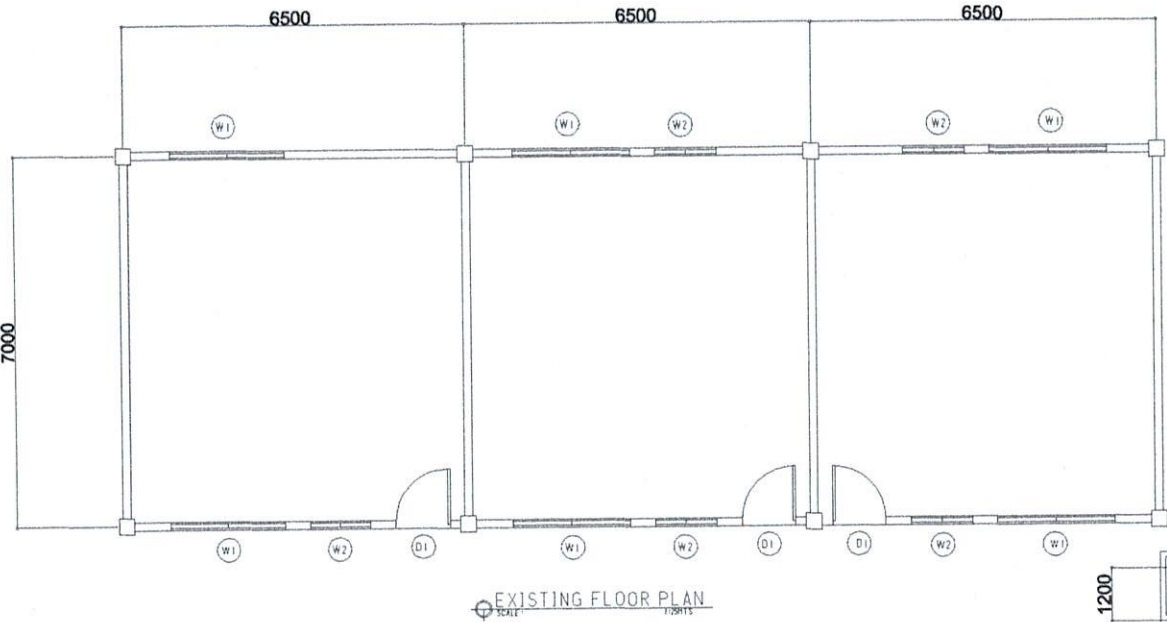


CITY ENGINEER'S
O F F I C E


PROJECT TITLE:	DRAWN BY:	RECOMMENDING APPROVAL :	APPROVED BY:
REPAIR/IMPROV. OF MULTI-PURPOSE HALL (BACON WEST CENTRAL SCHOOL)			
LOC: BACON DISTRICT SORSOGON CITY	Ma Pamela Legaspi DRAFTING AIDE	ROEL D. DOMER, C.E./RMP CITY ENGINEER	MA. ESTER E. HAMOR CITY MAYOR

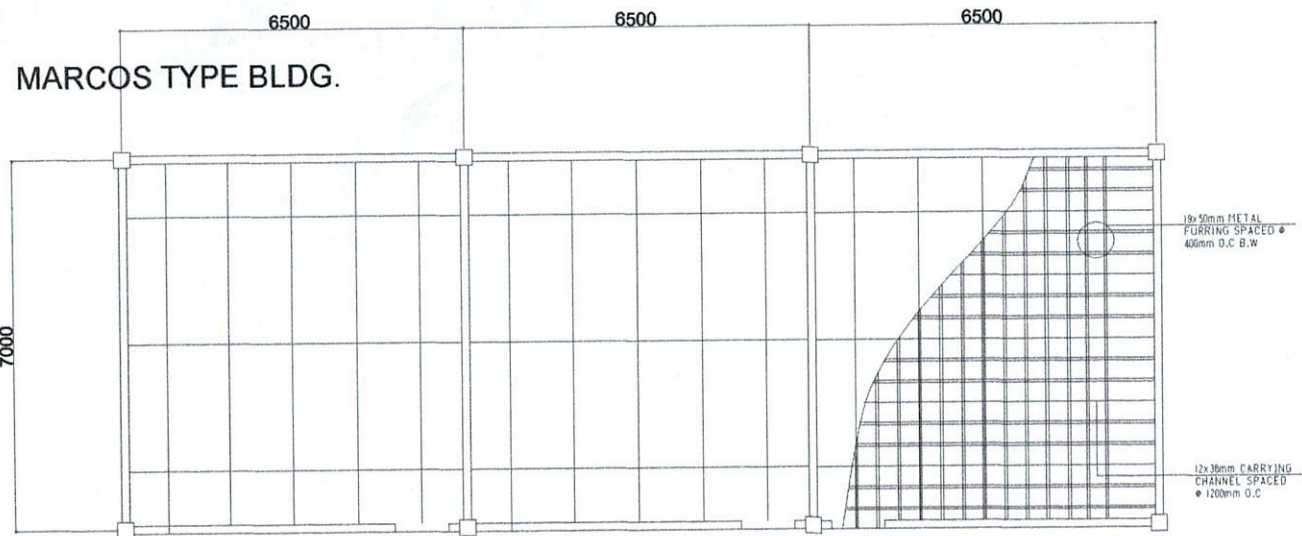

CEILING PLAN
SCALE: 1:250

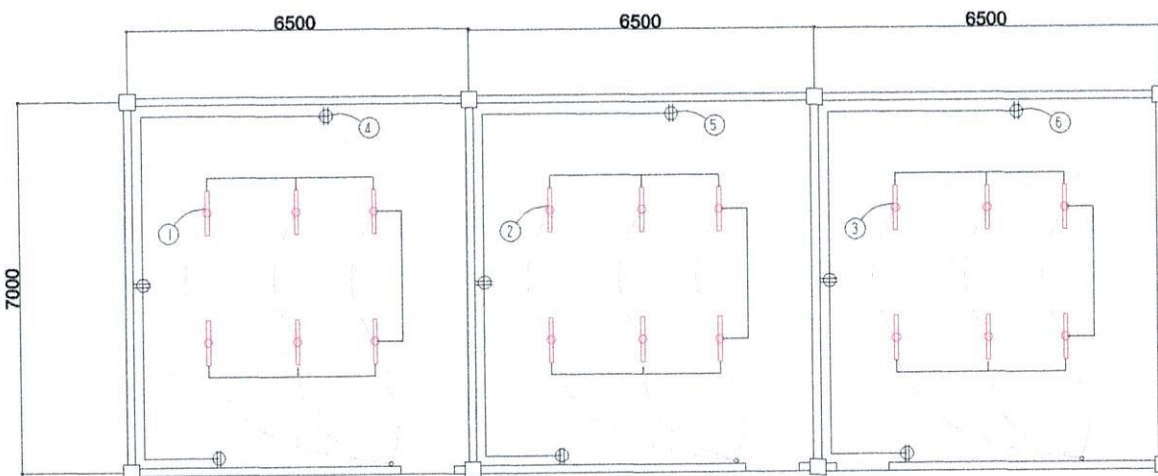

ELECTRICAL PLAN
SCALE: 1:250

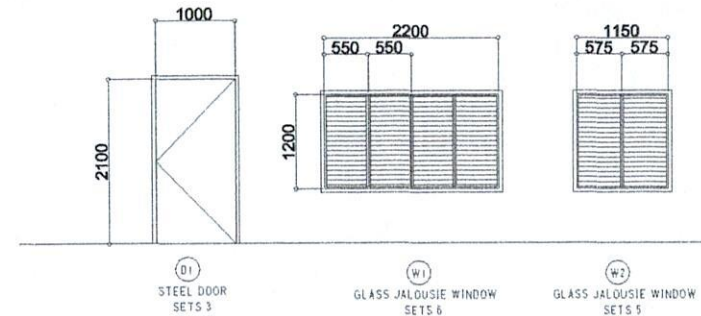

DOORS & WINDOWS SCHEDULE
SCALE: 1:250

SCHEDULE OF LOADS							
CIRCUIT NO.	DESCRIPTION	NO. OF LOADS	VOLTS	WATTS	AMP	SIZE OF WIRE	SIZE OF CONDUIT
1	LIGHTING OUTLET	6	230	600	2.60	2-2.0mm ² THW	15mmØ
2	LIGHTING OUTLET	6	230	600	2.60	2-2.0mm ² THW	15mmØ
3	LIGHTING OUTLET	6	230	600	2.60	2-2.0mm ² THW	15mmØ
4	CONVENIENCE OUTLET	3	230	540	2.34	2-3.5mm ² THW	20mmØ
5	CONVENIENCE OUTLET	3	230	540	2.34	2-3.5mm ² THW	20mmØ
6	CONVENIENCE OUTLET	3	230	540	2.34	2-3.5mm ² THW	20mmØ
TOTAL					24		

ELECTRICAL NOTES

ALL ELECTRICAL WORKS SHALL BE DONE IN ACCORDANCE WITH THE LATEST RULES AND REGULATIONS OF THE PHIL. ELECTRICAL CODE AS WELL AS THE LOCAL AUTHORITY CONCERNED AND THE LOCAL POWER COMPANY.

ALL ELECTRICAL MATERIALS TO BE USED SHALL BE NEED & APPROVED TYPE FOR LOCATION & PURPOSE

MOUNTING HEIGHTS SHALL BE AS FOLLOWS:

- a. LIGHT CONTROL SWITCH- 1.35M ABOVE FIN. FLR. LINE AT CENTER
- b. CONVENIENCE OUTLET-ABOVE 1.0M ABOVE FIN. FLR. LINE AT CENTER
- c. PANEL BOARD- 2.0 M ABOVE FIN. FLR. LINE

ALL ELECTRICAL WORKS SHALL BE UNDER THE DIRECT & IMMEDIATE SUPERVISION OF A DULY LICENSED ELECTRICAL ENGINEER OR REGISTERED MASTER ELECTRICIAN



CITY ENGINEER'S
OFFICE

PROJECT TITLE:

REPAIR/IMPROV. OF MULTI-PURPOSE HALL
(BACON WEST CENTRAL SCHOOL)

LOC: BACON DISTRICT
SORSOGON CITY

DRAWN BY:

MaPamela Legaspi
DRAFTING AIDE




RECOMMENDING APPROVAL :

ROEL B. DOMER, C.E./RMP
CITY ENGINEER

APPROVED BY:

MA. ESTER E. HAMOR
CITY MAYOR


2-STOREY BLDG.

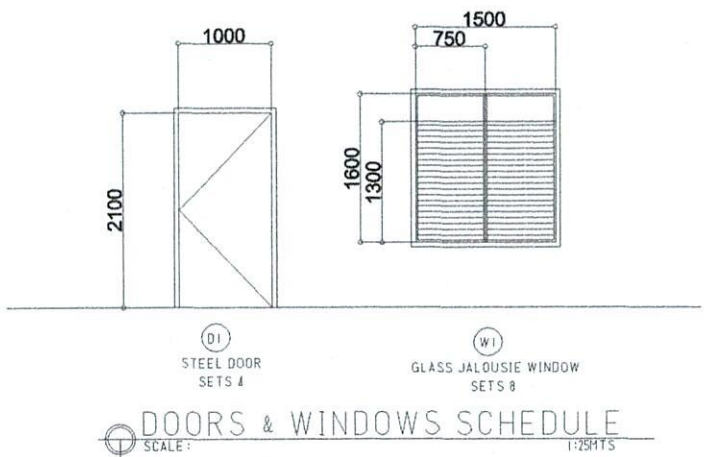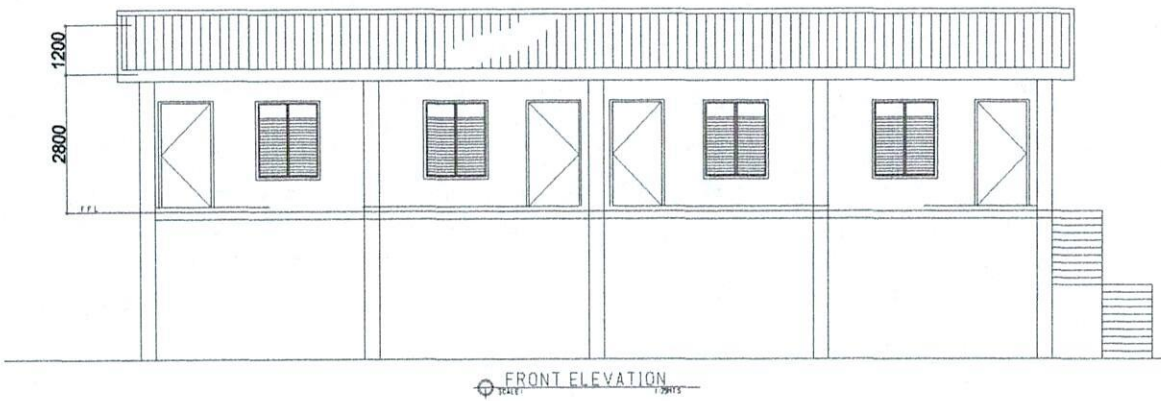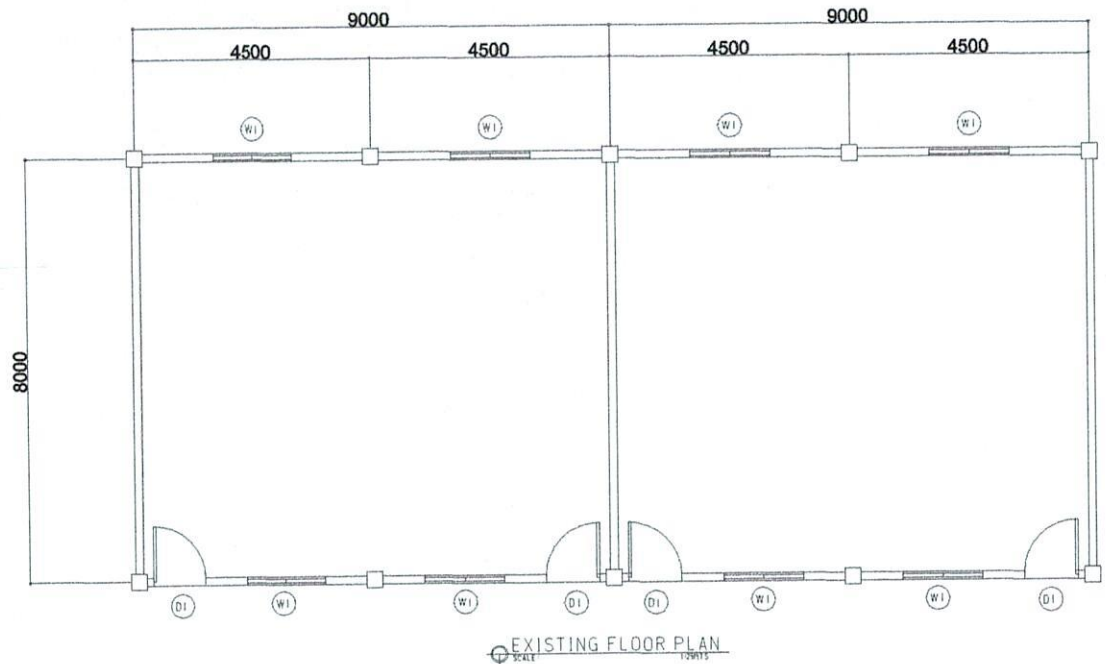


CITY ENGINEER'S
O F F I C E

PROJECT TITLE:	DRAWN BY:	RECOMMENDING APPROVAL :	APPROVED BY:
REPAIR/IMPROV. OF MULTI-PURPOSE HALL (BACON WEST CENTRAL SCHOOL)			
LOC: BACON DISTRICT	MaPamelaLegaspi	ROEL D. DOMER, C.E./RMP	MA. ESTER E. HAMOR
SORSOGON CITY	DRAFTING AIDE	CITY ENGINEER	CITY MAYOR

2-STOREY BLDG.

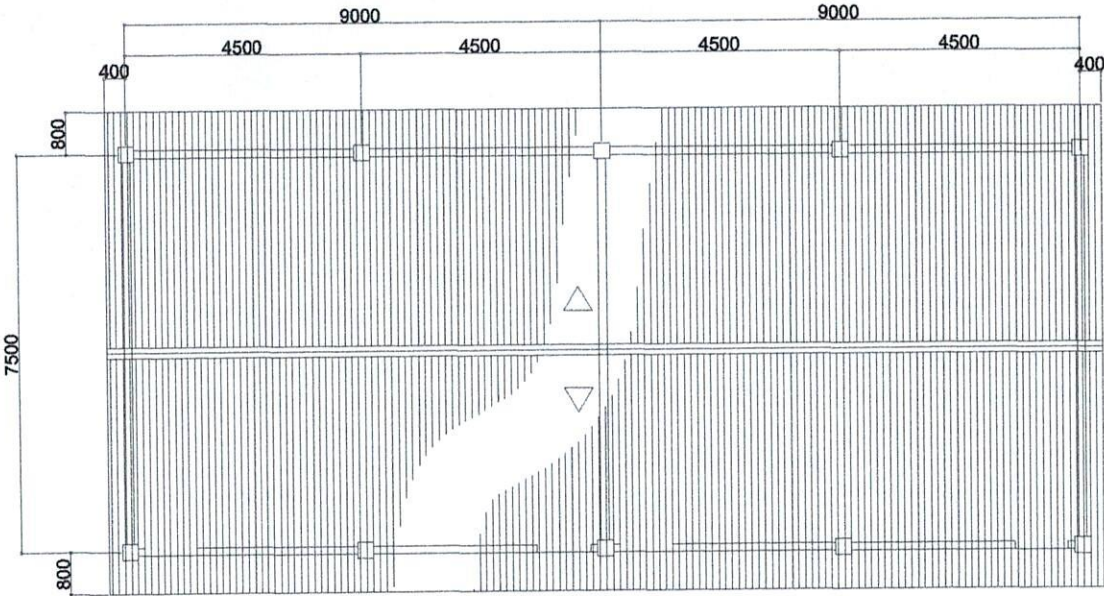

ROOF PLAN
SCALE: 1:200

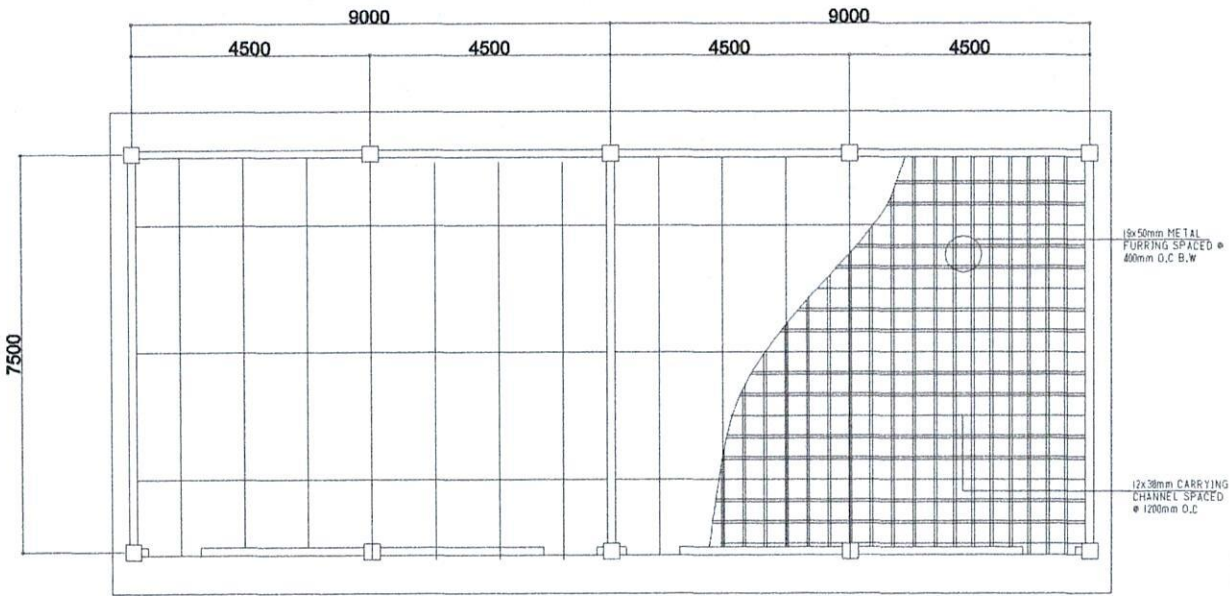


CEILING PLAN
SCALE: 1:200





CITY ENGINEER'S
O F F I C E

PROJECT TITLE:	DRAWN BY:	RECOMMENDING APPROVAL :	APPROVED BY:
REPAIR/IMPROV. OF MULTI-PURPOSE HALL (BACON WEST CENTRAL SCHOOL)			
LOC: BACON DISTRICT	MaPamela Legaspi	ROEL D. DOMER, C.E./RMP	MA. ESTER E. HAMOR
SORSOGON CITY	DRAFTING AIDE	CITY ENGINEER	CITY MAYOR

2-STOREY BLDG.

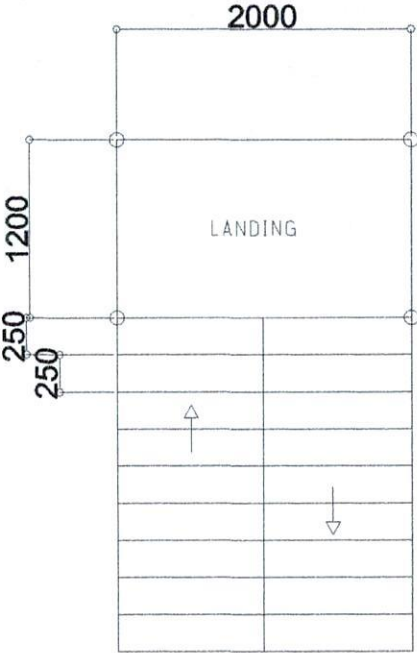

PLAN

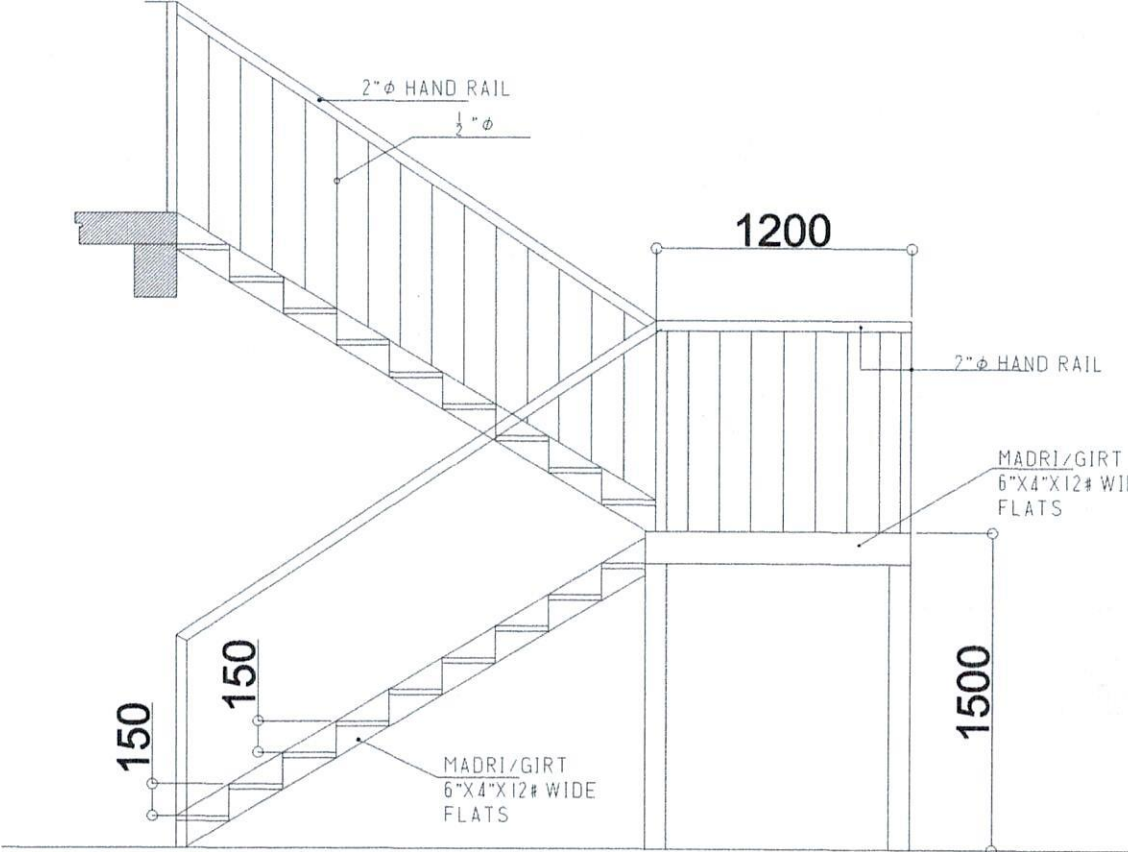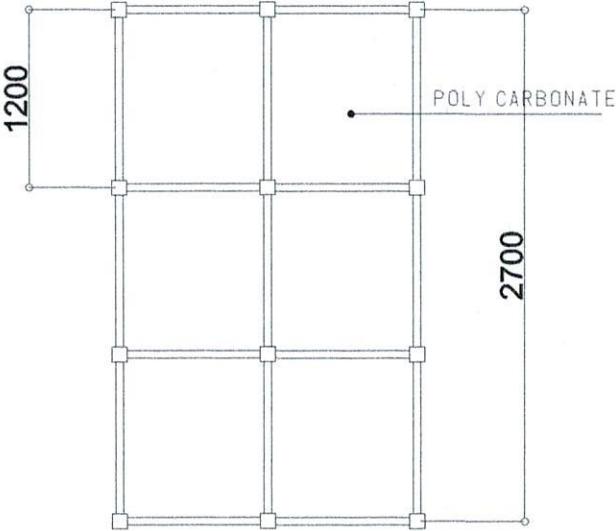

DET OF STAIRS



CITY ENGINEER'S
O F F I C E

PROJECT TITLE:	DRAWN BY:	RECOMMENDING APPROVAL :	APPROVED BY:
REPAIR/IMPROV. OF MULTI-PURPOSE HALL (BACON WEST CENTRAL SCHOOL)			
LOC: BACON DISTRICT	MaPamelaLegaspi	ROEL D. DOMER, C.E./RMP	MA. ESTER E. HAMOR
SORSOGON CITY	DRAFTING AIDE	CITY ENGINEER	CITY MAYOR